

Full Size

8.5 x 11


11 x 17

(site plan, landscape, elevations)

OWNER
DFN COMMUNITY, LLC
3200 E. CAMELBACK ROAD, STE. 295
PHOENIX, AZ 85018
(602) 474-0604
CONTACT: FRANCIS NAJAFI

ARCHITECT
DOUGLAS FREDRICKSON ARCHITECTS
727 E. BETHANY HOME ROAD, SUITE D-123
PHOENIX, AZ 85014
PH: (602) 277-1625
CONTACT: ALBERTO VARELA

ENGINEER
ERICKSON & MEEKS ENGINEERING, L.L.C.
13444 N. 32ND ST., SUITE 6
PHOENIX, ARIZONA 85032
PH: 602-569-6593
FX: 602-569-6493
CONTACT: JEFF ERICKSON

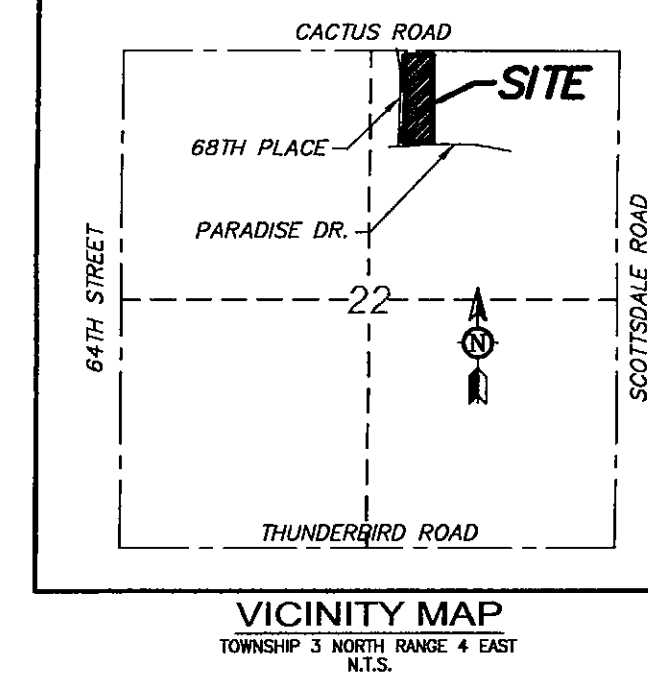




BASIS OF BEARING
THE NORTH LINE OF THE NORTHEAST QUARTER OF SECTION 22,
TOWNSHIP 3 NORTH RANGE 4 EAST OF THE GILA AND SALT RIVER
BASE AND MERIDIAN. SAID LINE BEARS NORTH 90°00'00" EAST.

SITE AREA
LOT 1 CONTAINS 272,479 SQUARE FEET OR 6.255 ACRES

APN
175-20-005, 170-20-006, 170-20-007


FLOOD ZONE
ACCORDING TO THE FLOOD INSURANCE RATE MAP #04013C1685F,
DATED SEPTEMBER 30, 2005, THIS PROPERTY IS LOCATED IN FLOOD
ZONE "X".

PRELIMINARY
NOT FOR CONSTRUCTION
OR RECORDING

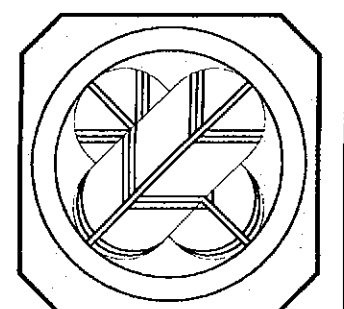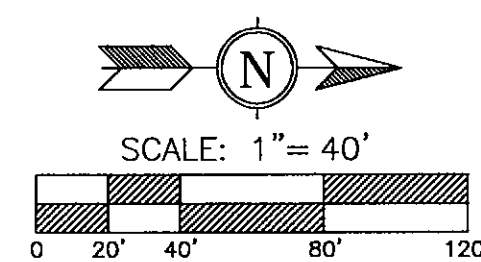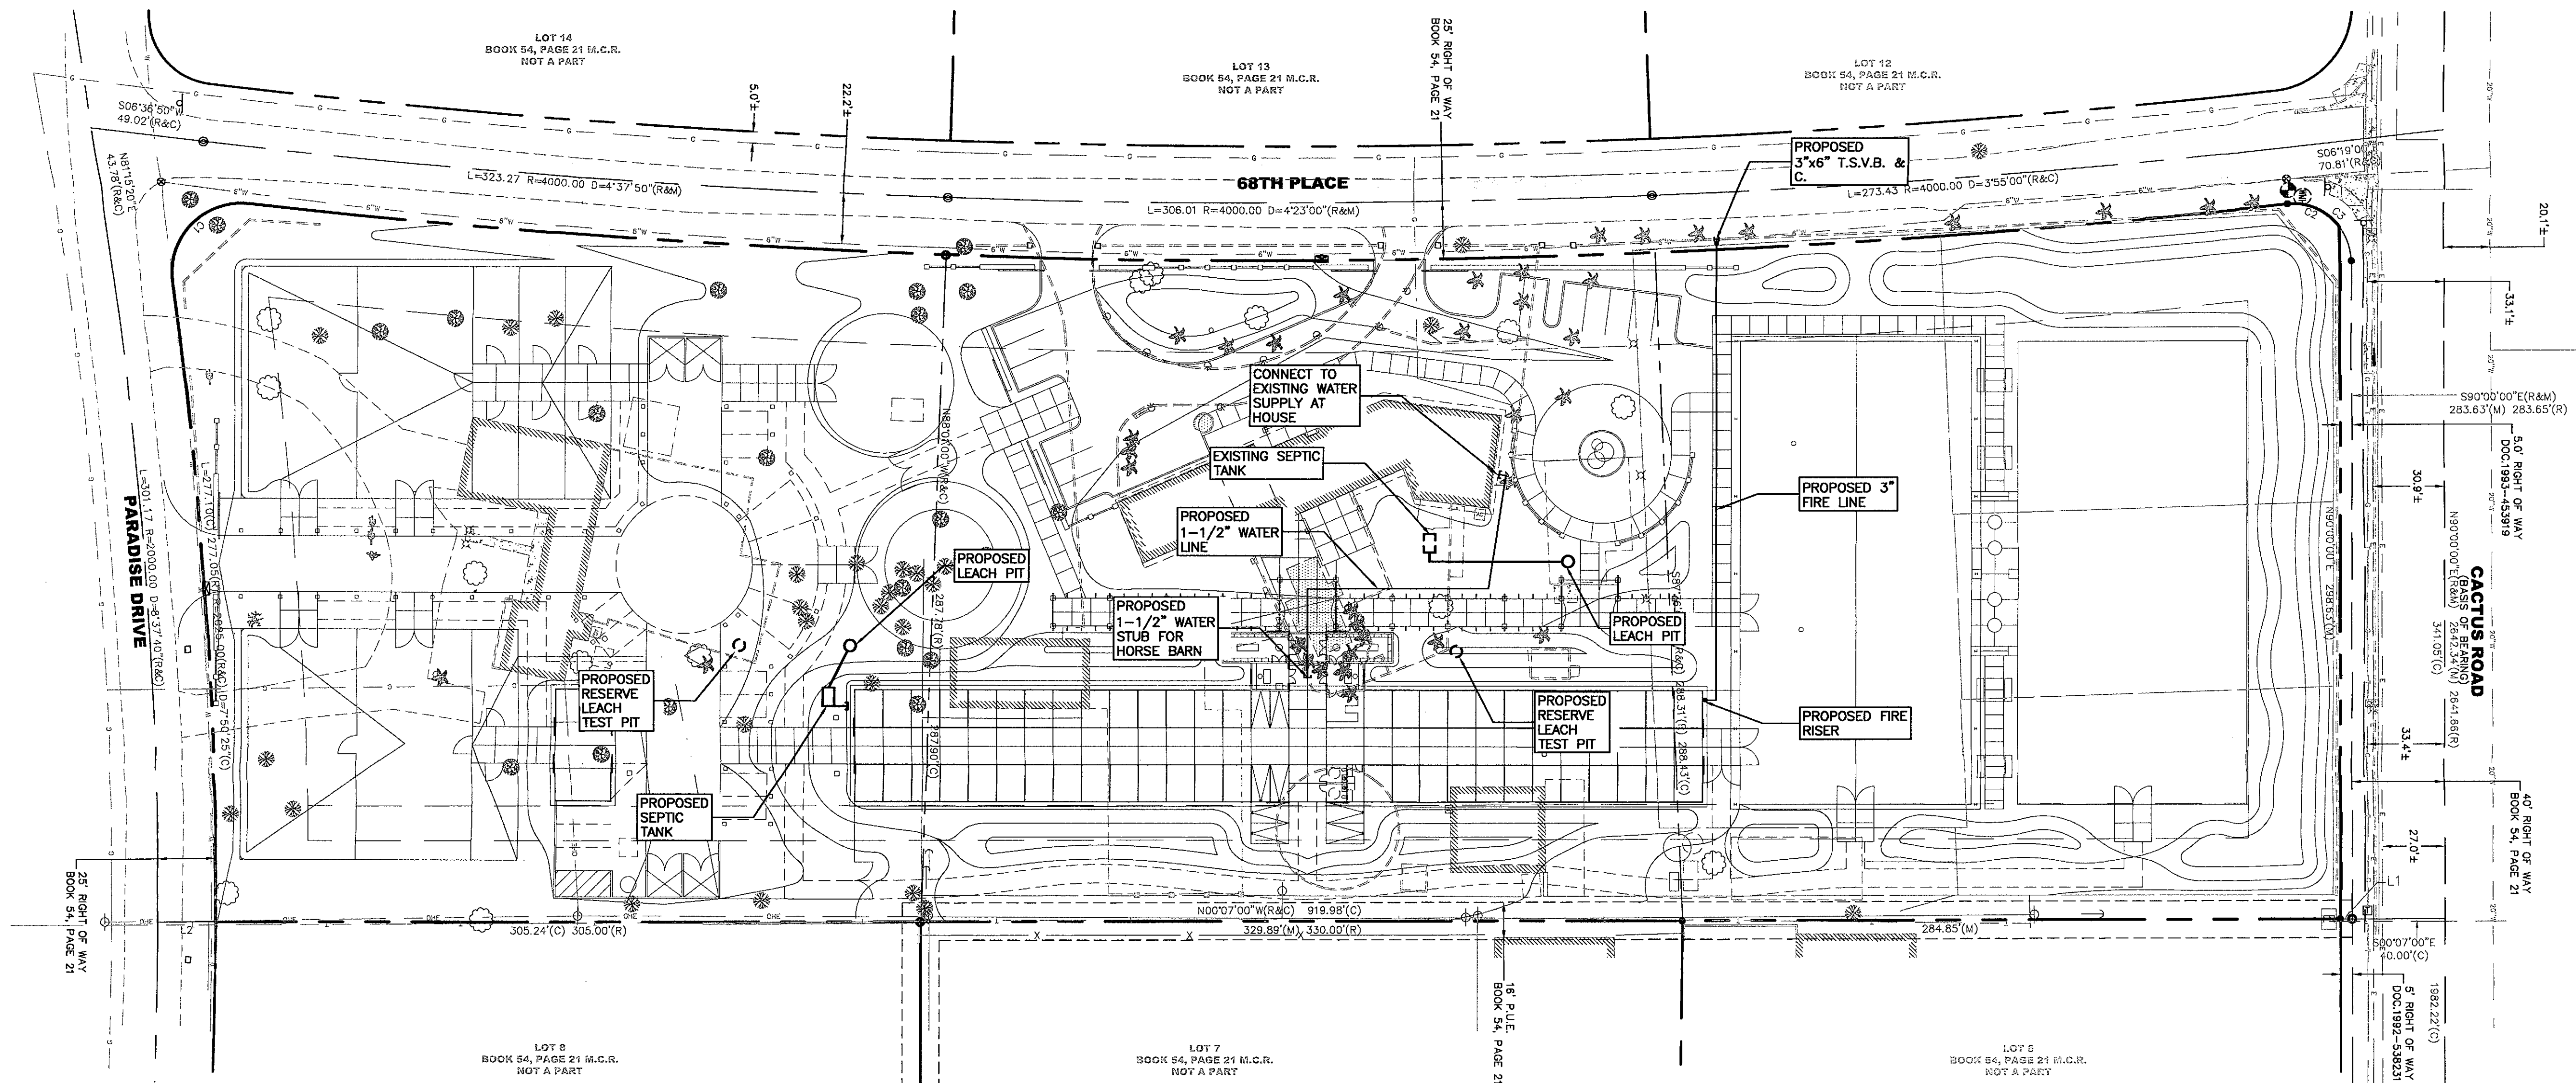

EME

**Erickson & Meeks
Engineering, L.L.C.**
13444 N. 32nd Street
Suite 6
Phoenix, Arizona 85032
Phone: (602) 569-6593
Fax: (602) 569-6493

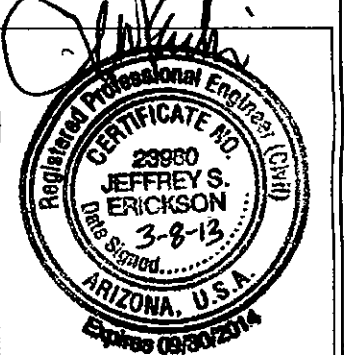

NAJAFI RANCH HOME CONCEPTUAL UTILITY PLAN SCOTTSDALE, ARIZONA



REVISIONS	

DATE: 03/08/13
PROJ. NO: 213-005
DESIGN: JE
DRAWN: JG
CHECK: JE
SCALE: 1"=40'
CAD FILE: 1305cu

CU1
1 of 1



 context plan
scale: 1" = 100'-0"

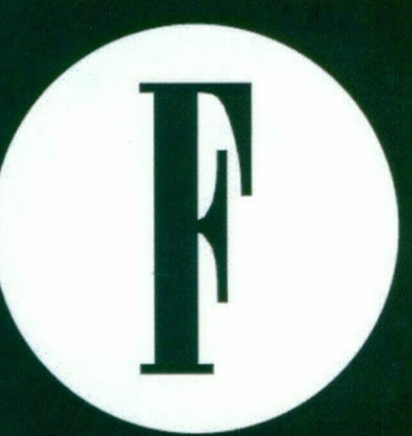


NAJAFI RANCH
525 BOYNTON CANYON ROAD




Douglas Fredrikson Architects
727 east bethany home road, d-123
phoenix, arizona 85014
602.277.1625

these documents are instruments of service of the authors and are for use on this project only. they are prepared for use in conjunction with the authors interpretations, observations, decisions, and administration as described in the addendum. without which desired result can not be assured. alteration, reproduction, or use in part or in whole for other purposes without the authors written consent may violate existing legal statutes.

13100
site plan
issue date
10.25.2015
revisions

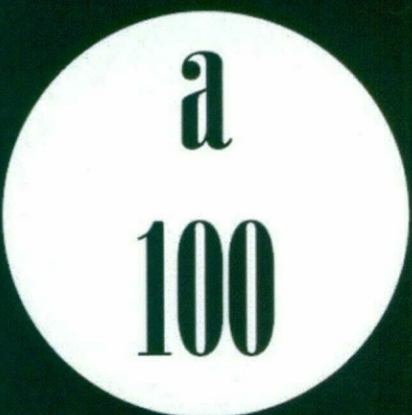

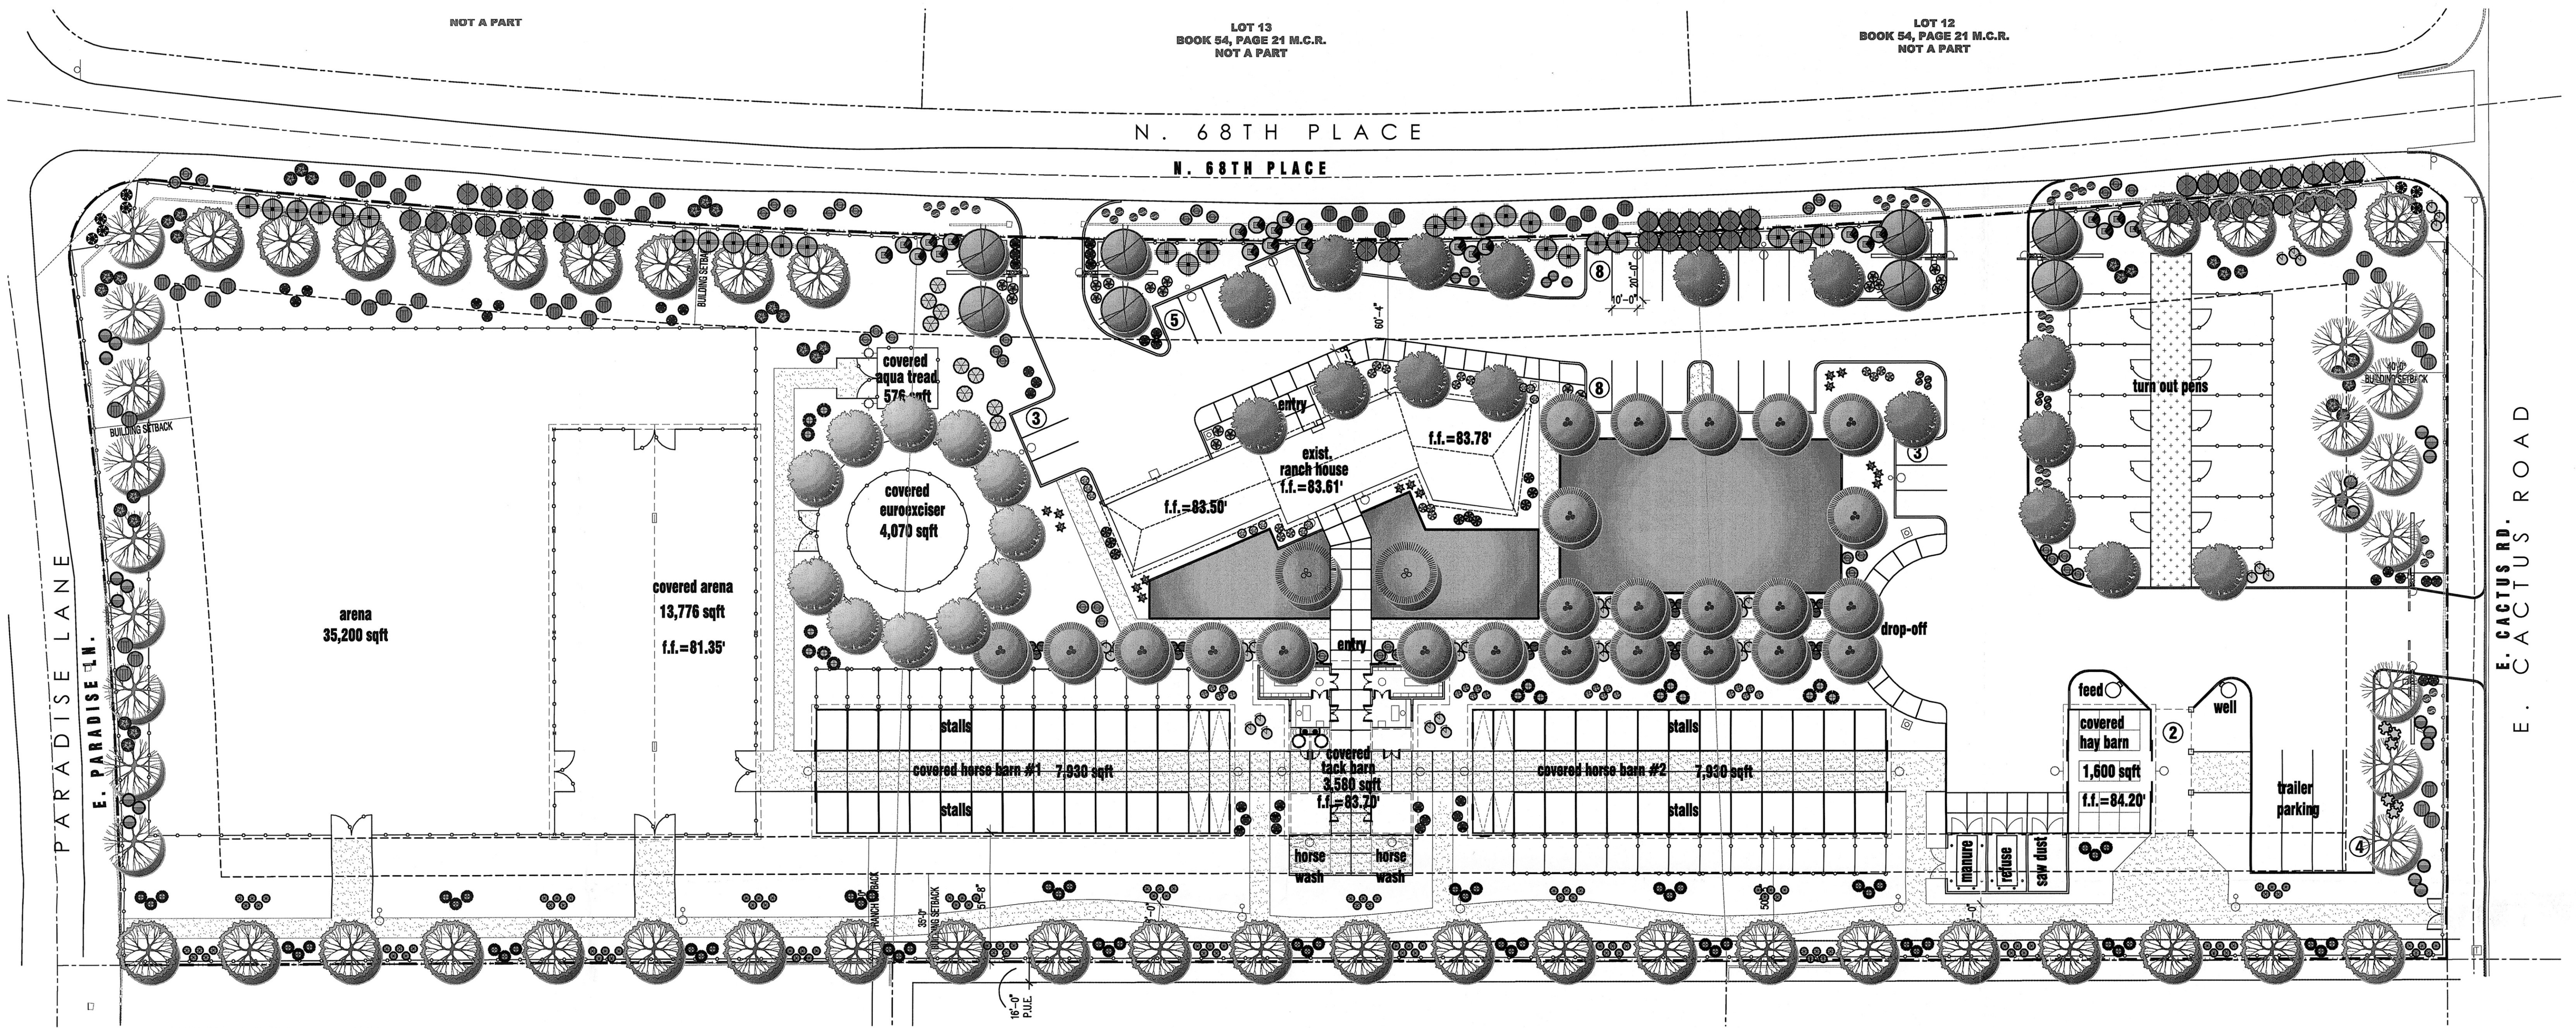

PLANT MATERIALS LEGEND

Sym. Plant Name

Trees Size Qty

	<i>Fraxinus velutina</i> 'Rto-Grande'	15 Gallon	58
	Fan-Tax Ash		
	<i>Olea europaea</i> 'Swan Hill'	24" Box	19
	Swan Hill Olive		
	<i>Platanus wrightii</i>	24" Box	2
	Arizona Sycamore		
	<i>Pistacia x 'Red Push'</i>	24" Box	24
	Red Push Pistache		
	<i>Pyrus calleryana</i>	24" Box	8
	Bradford Pear		
	<i>Quercus virginiana</i> 'Cathedral Oak'	24" Box	11
	Cathedral Oak		
	<i>Ulmus parvifolia</i> 'True Green'	24" Box	17
	True Green Elm		

Shrubs

	<i>Callistemon viminalis</i> 'Little John'	5 gal.	41
	Boylebrush		
	<i>Convolvulus cneorum</i>	5 gal.	42
	Bush Morning Glory		
	<i>Cordia parvifolia</i>	5 gal.	27
	Little Leaf Cordia		
	<i>Dalea capitata</i>	5 gal.	-
	Golden Dalea		
	<i>Dodonaea viscosa</i> 'Purpurea'	5 gal.	45
	Purple Hop Bush		
	<i>Eremophila hygrophana</i> 'Blue Bells'	5 gal.	21
	Blue Bells Eremophila		

Groundcovers

	<i>Eremophila maculata</i> 'Valentine'	5 gal.	9
	Valentine Shrub		
	<i>Larrea tridentata</i>	5 gal.	-
	Creosote		
	<i>Leucophyllum langmaniae</i> 'Lynn's Legacy'	5 gal.	16
	Lynn's Legacy Sage		
	<i>Leucophyllum laevigatum</i>	5 gal.	57
	Chihuahuan Sage		
	<i>Leucophyllum zygophyllum</i>	5 gal.	9
	Blue Ranger		
	<i>Ruellia brittoniana</i>	5 gal.	20
	Ruellia		
	<i>Ruellia equisetiformis</i>	5 gal.	110
	Coral Fountain		
	<i>Salvia coccinea</i>	5 gal.	-
	Scarlet Sage		
	<i>Senna nemophila</i>	5 gal.	-
	Desert Senna		
	<i>Tecoma stans</i>	5 gal.	24
	Yellow Bells		

Accents/Cacti

	<i>Aloe barbadensis</i>	5 gal.	16
	Medicinal Aloe		
	<i>Aloe x 'Blue Elf'</i>	5 gal.	11
	Blue Elf Aloe		
	<i>Agave desertiana</i>	5 gal.	15
	Tropical Agave		
	<i>Dasylistron longissimum</i>	5 gal.	8
	Mexican Grass Tree		
	<i>Hesperaloe parviflora-perpa</i>	5 gal.	40
	Brakeflights Red Yucca		
	<i>Muhlenbergia capillaris</i> 'Regal Mist'	5 gal.	20
	Regal Mist TM		
	<i>Muhlenbergia lindheimeri</i> 'Autumn Glow'	5 gal.	35
	Autumn Glow TM		
	<i>Pedilanthus macrocarpus</i>	5 gal.	9
	Lady's Slipper		

MASS PLANTING


	TURF- 11,000 S.F.
--	-------------------

INERTS

Sym.	Description
	DECOMPOSED GRANITE.
	1/2" EXPRESS GOLD


NOTES:

- ALL PLANTS SHALL BE WATERED WITH AN AUTOMATIC DRIP IRRIGATION SYSTEM.
- ALL LANDSCAPE AREAS EXCLUDING TURF TO BE COVERED WITH CRUSHED ROCK.
- LANDSCAPE ARCHITECT TO APPROVE FINAL GRADING. PLANTING SHALL NOT OCCUR UNTIL FINAL GRADING IS APPROVED.
- ALL SHRUBS TO BE PLANTED 3'-0" MIN. AWAY FROM EXISTING OR FUTURE WALLS.
- ALL TREES TO BE PLANTED 5'-0" AWAY FROM EXISTING OR FUTURE WALLS.
- ALL TREES SHALL BE PLANTED MIN. 5'-0" AWAY FROM WALKS, CURBS AND WALLS. SHRUBS TO BE 2'-0" MIN. THE SAME.
- THE MAXIMUM HEIGHT OF ANY SHRUBS, PLANTS, BOULDERS AND WALLS WITHIN A SVT SHALL NOT EXCEED 18 INCHES. ANY TREES PLACED WITHIN THE SVT SHALL HAVE A CANOPY THAT IS KEPT AT 8' ABOVE THE CURB HEIGHT AND A MAX. MATURE TRUNK DIA. OF 8".
- TREES, SAGUAROS OR IN-LINE WALLS SHOULD BE PLACES AT LEAST 7 FEET BACK FROM ANY UNDERGROUND PUBLIC WATER LINE, SEWER LINE OR POWER CONDUIT LINE.

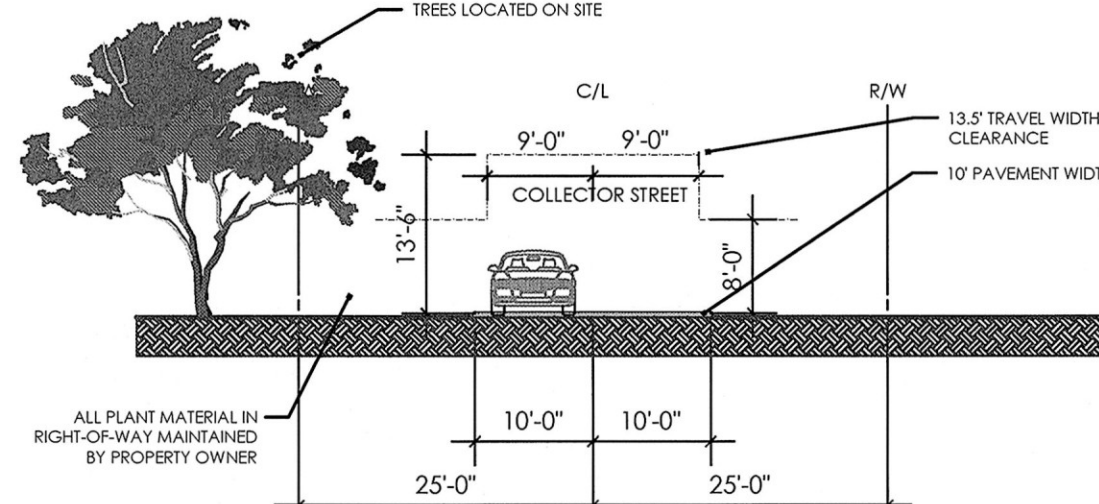

1 Residential Roadway Clearance Detail
Scale: 1/16" = 1'-0"

Najafi Ranch Scottsdale, Arizona

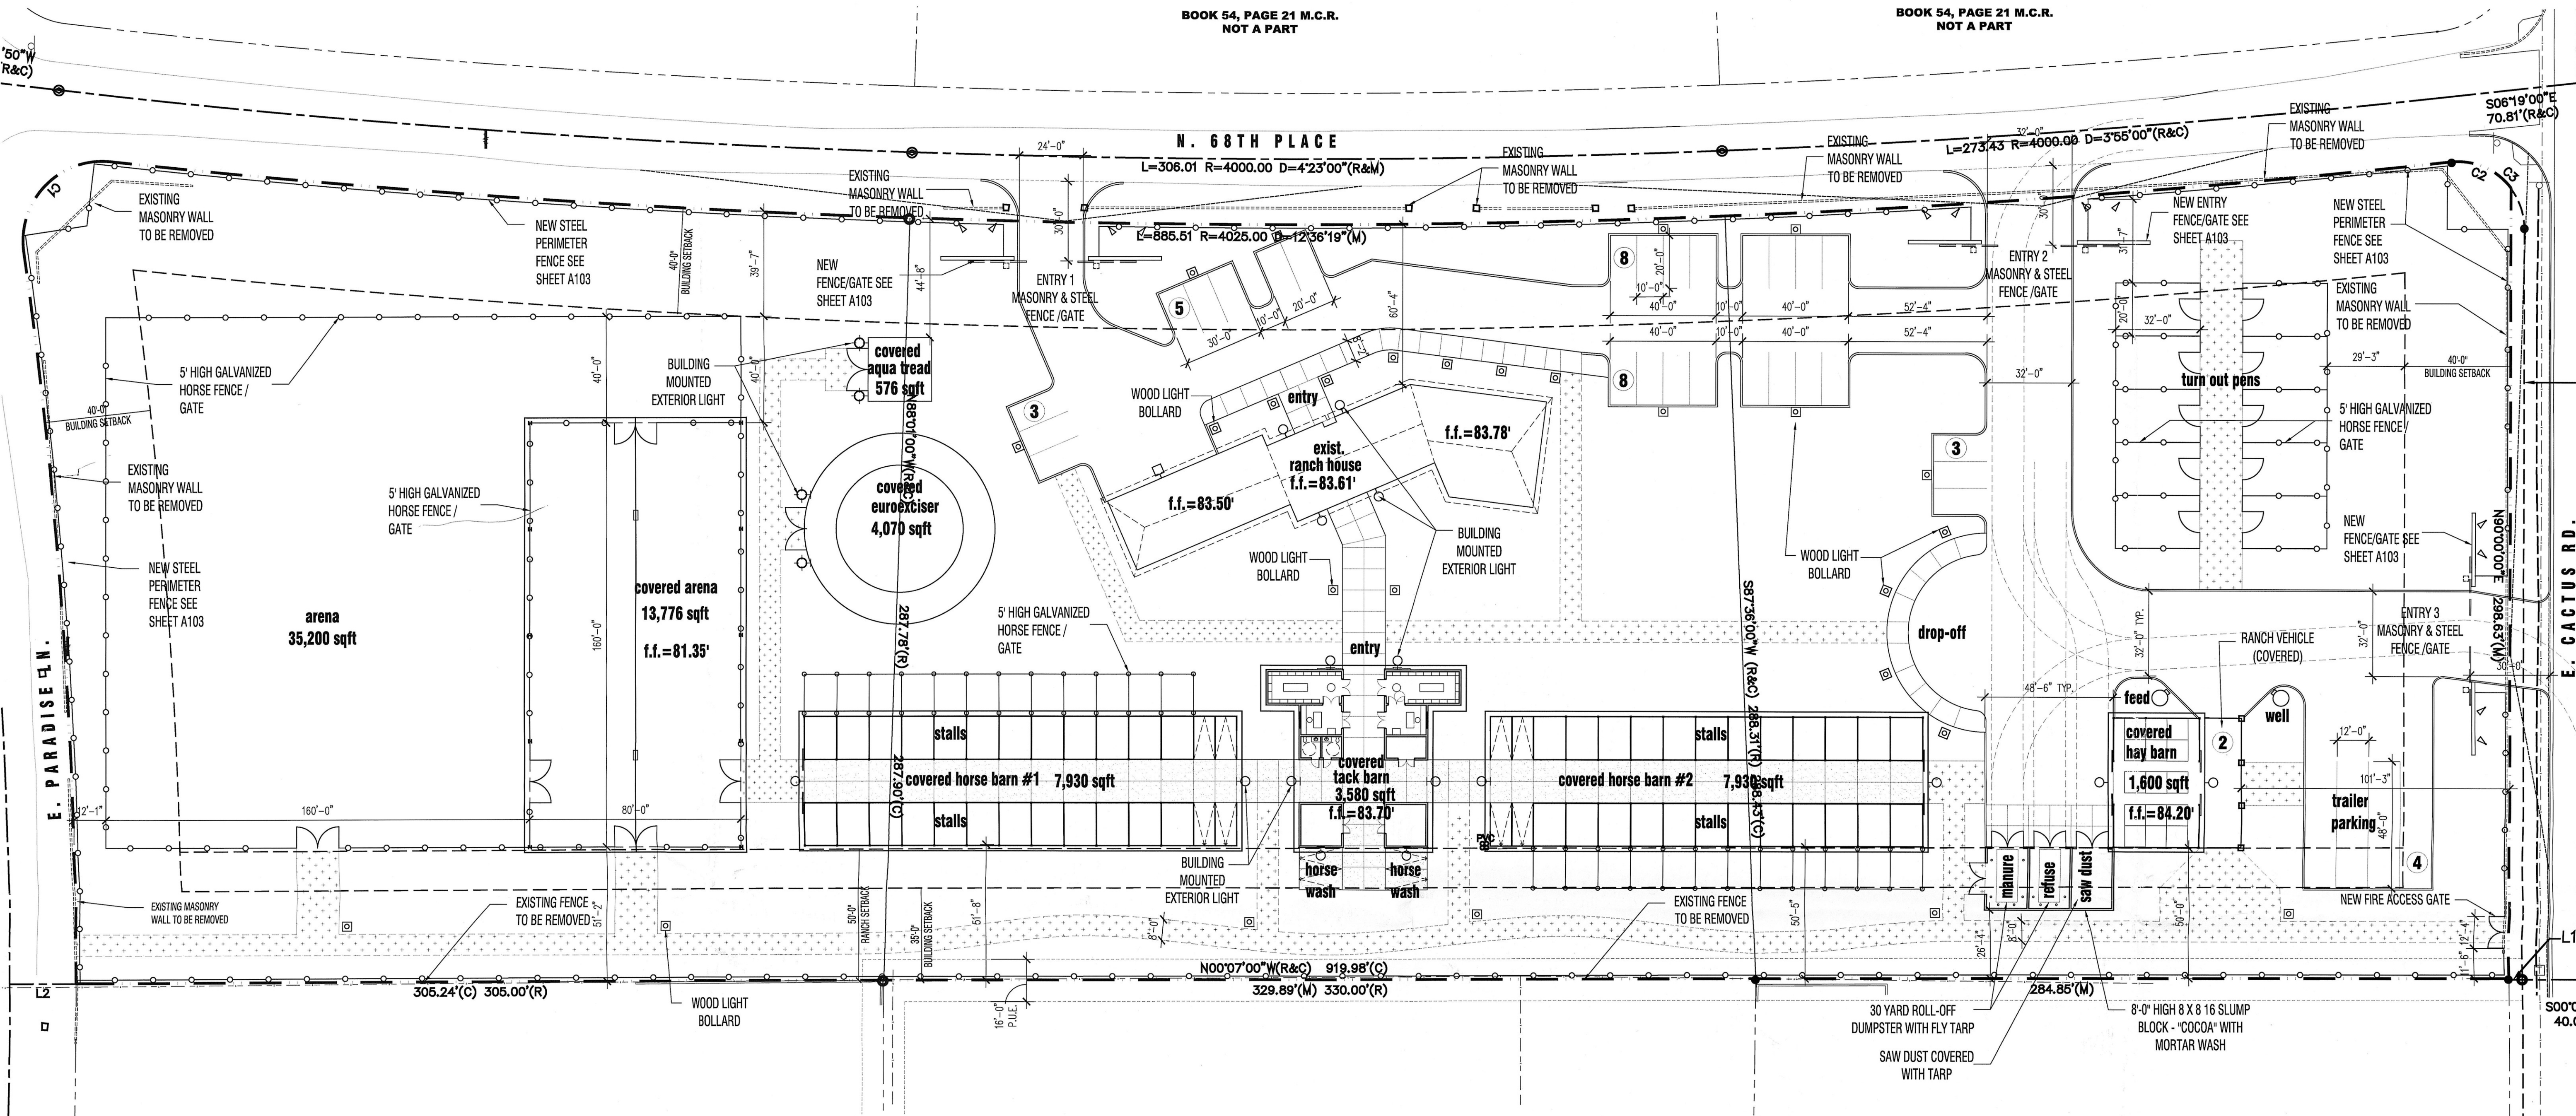

Project Data


Assessors Parcel Number:	175-20-05, 175-20-06, 175-20-07	Parking Required:	
Site Area:	272,479 S.F. (±6.255 acres)	1 Parking Space / 2 Stalls - Accessible - Bicycle	26 Parking Spaces Not Required per R1-35 Zoning Not Required per R1-35 Zoning
Existing Zoning:	R1-35 Residential	Proposed Parking:	
Proposed Zoning:	R1-35 / Conditional Use Permit - Ranch	- Parking Spaces Vehicular only (10 x 20) - Parking Spaces Truck / Trailer (12 x 48) - Ranch Vehicle Parking (Covered)	27 Parking Spaces 4 Parking Spaces 2 Parking Spaces
Proposed Buildings (Roofed)			
- Existing Ranch House - New Horse / Tack Barn - New Hay Barn	Existing 19,440 SF 1,600 SF		
Proposed Accessory Structures (Roofed)			
- New Covered Arena - New Eurociser - New Aqua Tread	13,776 SF 4,070 SF 576 SF		
Proposed Accessory Structures			
(1) Manure Storage 8ft Enclosure Wall (1) Sawdust Storage 8ft Enclosure Wall (1) Refuse Storage 8ft Enclosure Wall	389 SF 389 SF 389 SF		
Proposed Equestrian Fenced Areas (Not Roofed)			
- Pasture (10) 20 X 32 Turnout Pens	35,200 SF 6,400 SF		

General Notes

- At time of final plans the owner shall submit verification that the existing walls located within the right of way have been removed
- An additional hydrant will be required to protect the property
- The horse barn will require a separate fire line service for the sprinkler system
- An FDC will be required near N. 68th St.
- Fire access system (knob box / switch) will be required for gates
- Renovations/additions to existing residence exceeding 25% value of existing home will require installation of fire sprinkler system
- The covered arena must comply as an open equestrian arena for riding only to be exempted from fire sprinklers
- The existing on-site well shall comply with ADWR and MCESD
- Additional water development fees will be due based on the area of the north lot
- Pole mounted lights are not to exceed 16'-0" in height

site plan

scale: 1" = 30'-0"

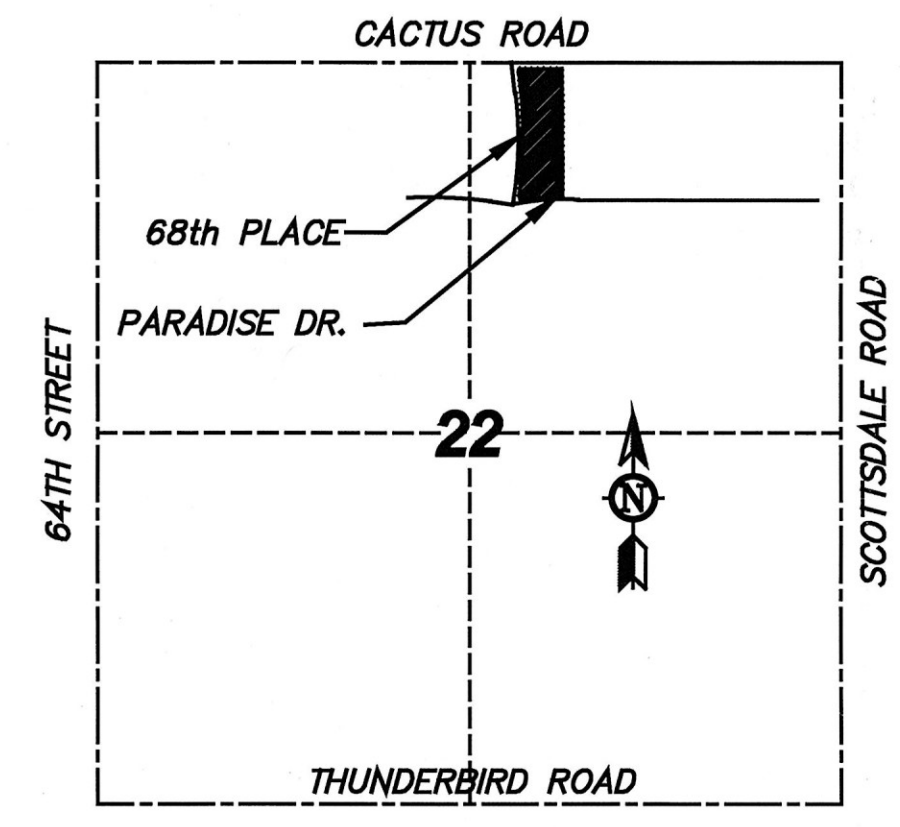


vicinity map

scale: n.t.s.



NAJAFI RANCH
525 BOYNTON CANYON ROAD





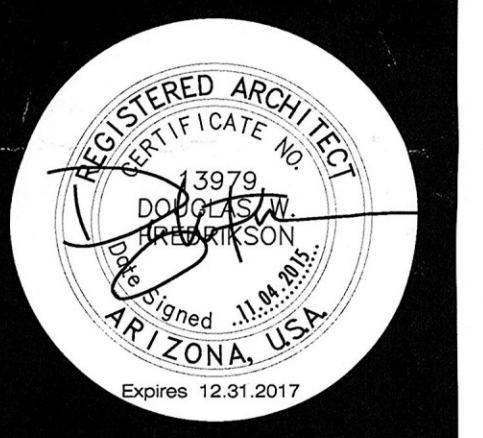


Douglas Fredrikson Architects
727 east bethany home road, d-123
phoenix, arizona 85014
602.277.1625

these documents are instruments of service of the authors and are for use on this project only. they are prepared for use in conjunction with the authors interpretations, observations, decisions, and administration as described in this document. without which desired result can not be assured. alteration, reproduction, or use in part or in whole, for other purposes without the authors written consent may violate existing legal statutes.

13100
site plan
issue date
10.25.2015
revisions

a
101

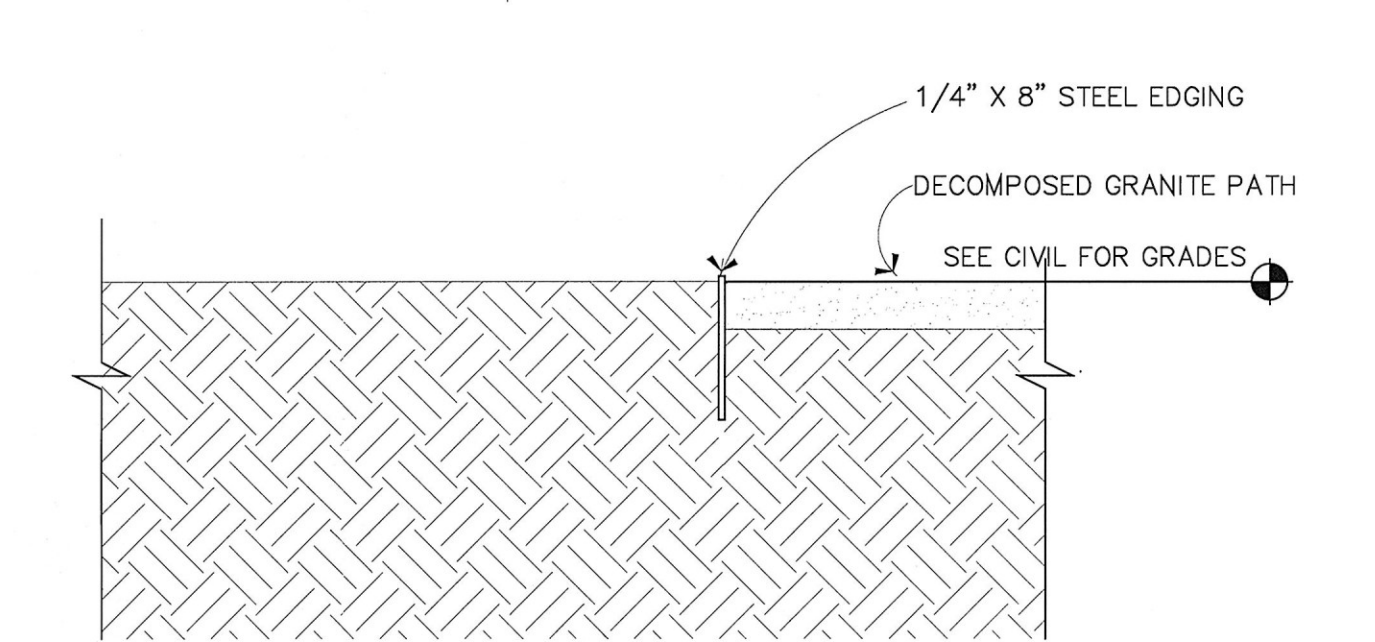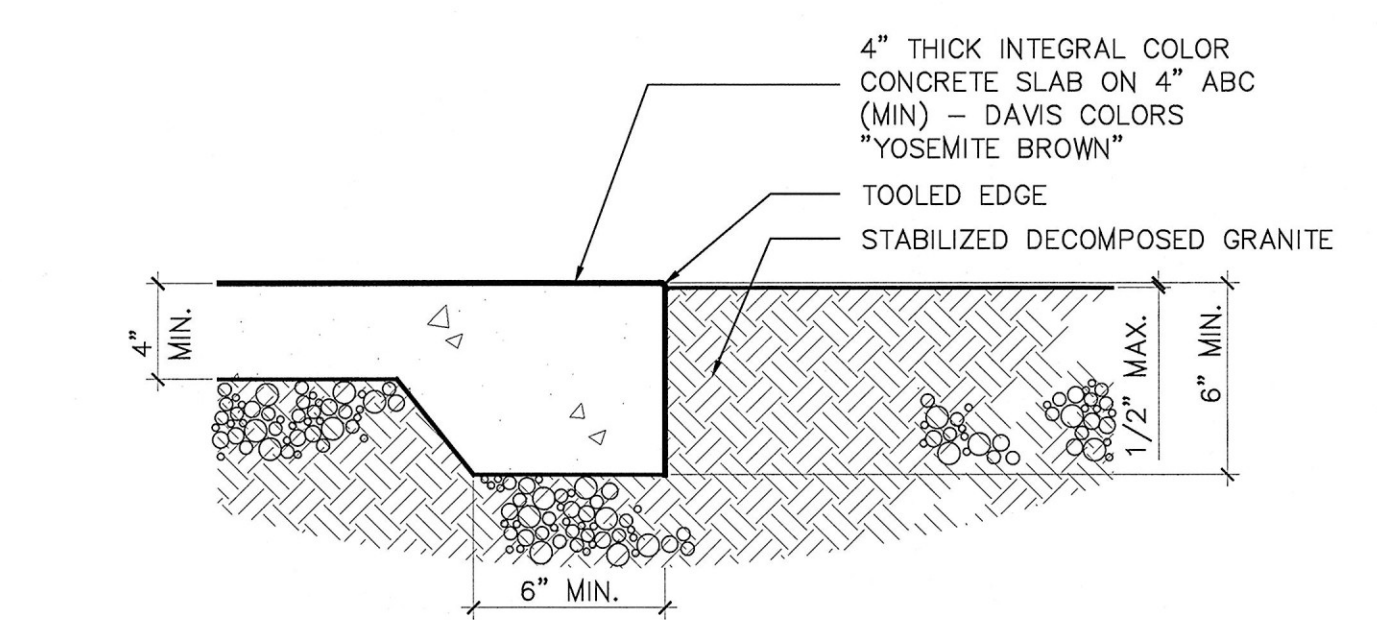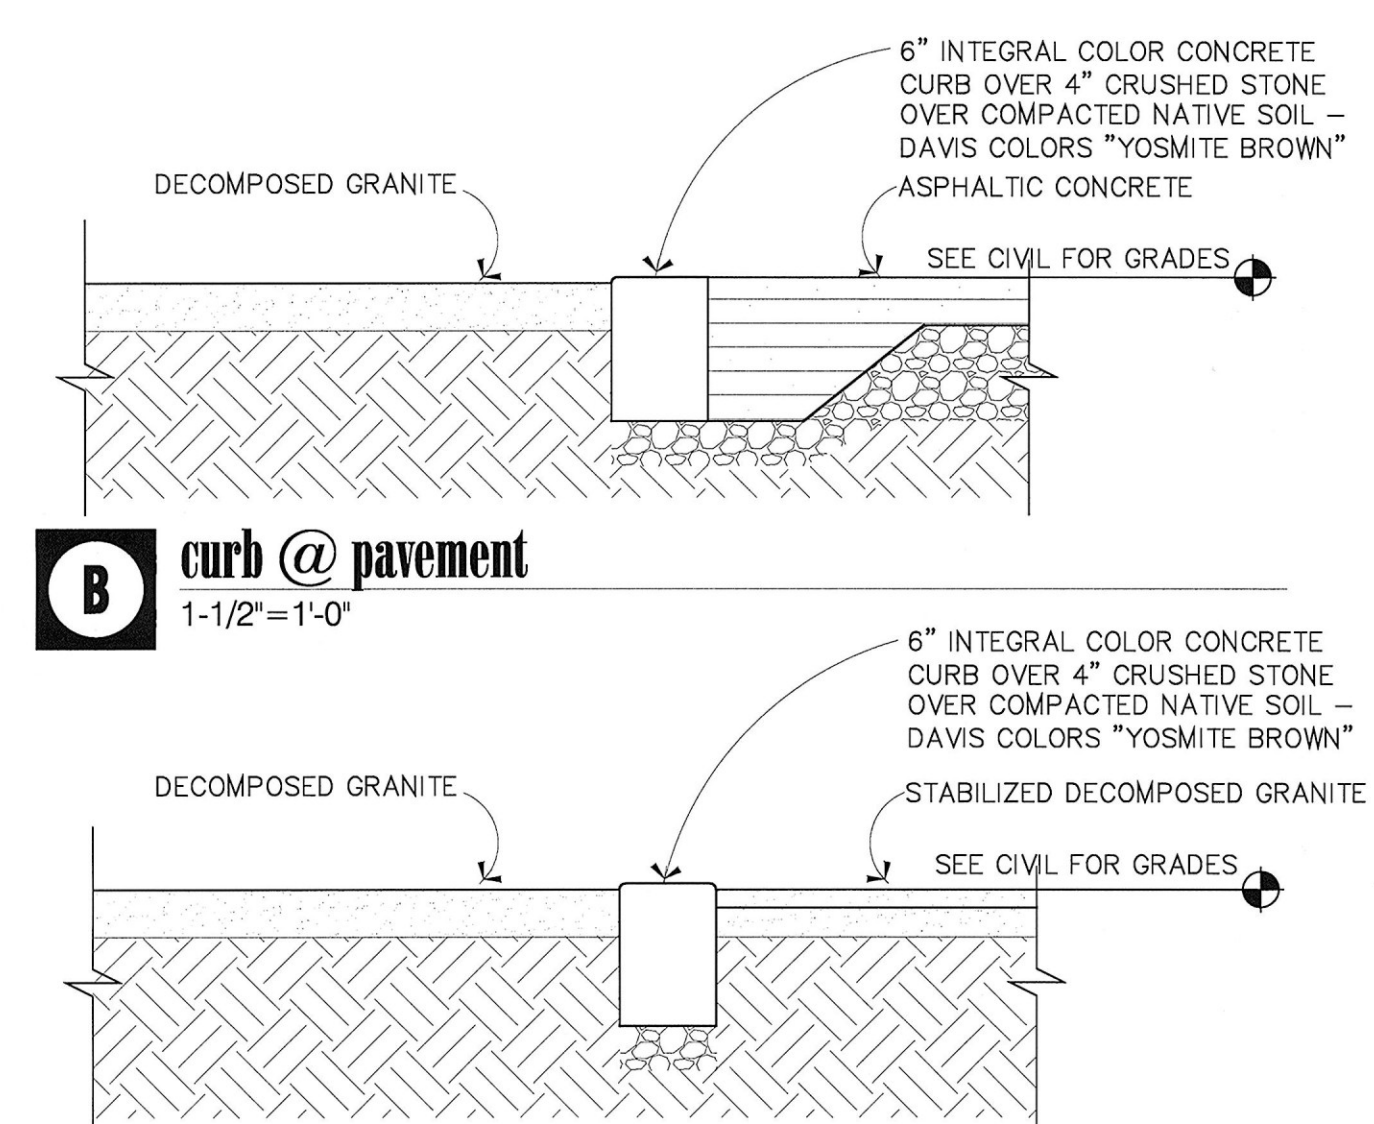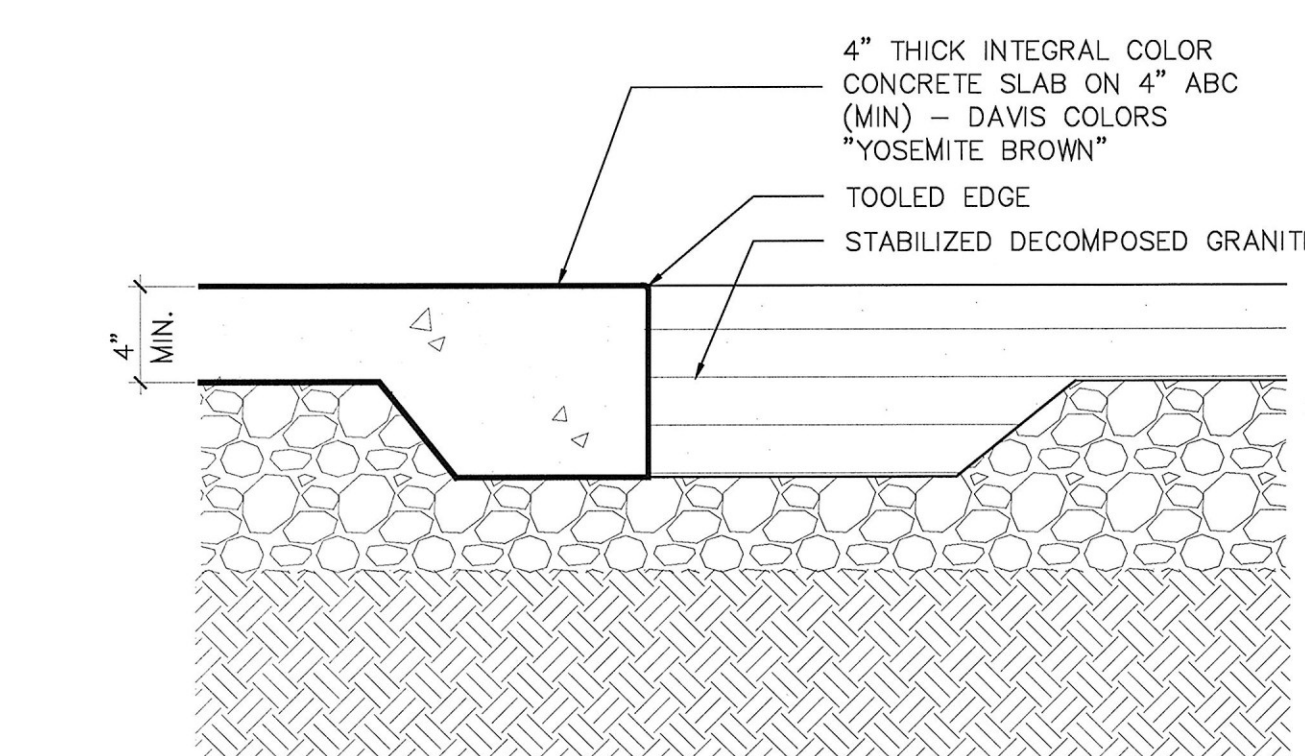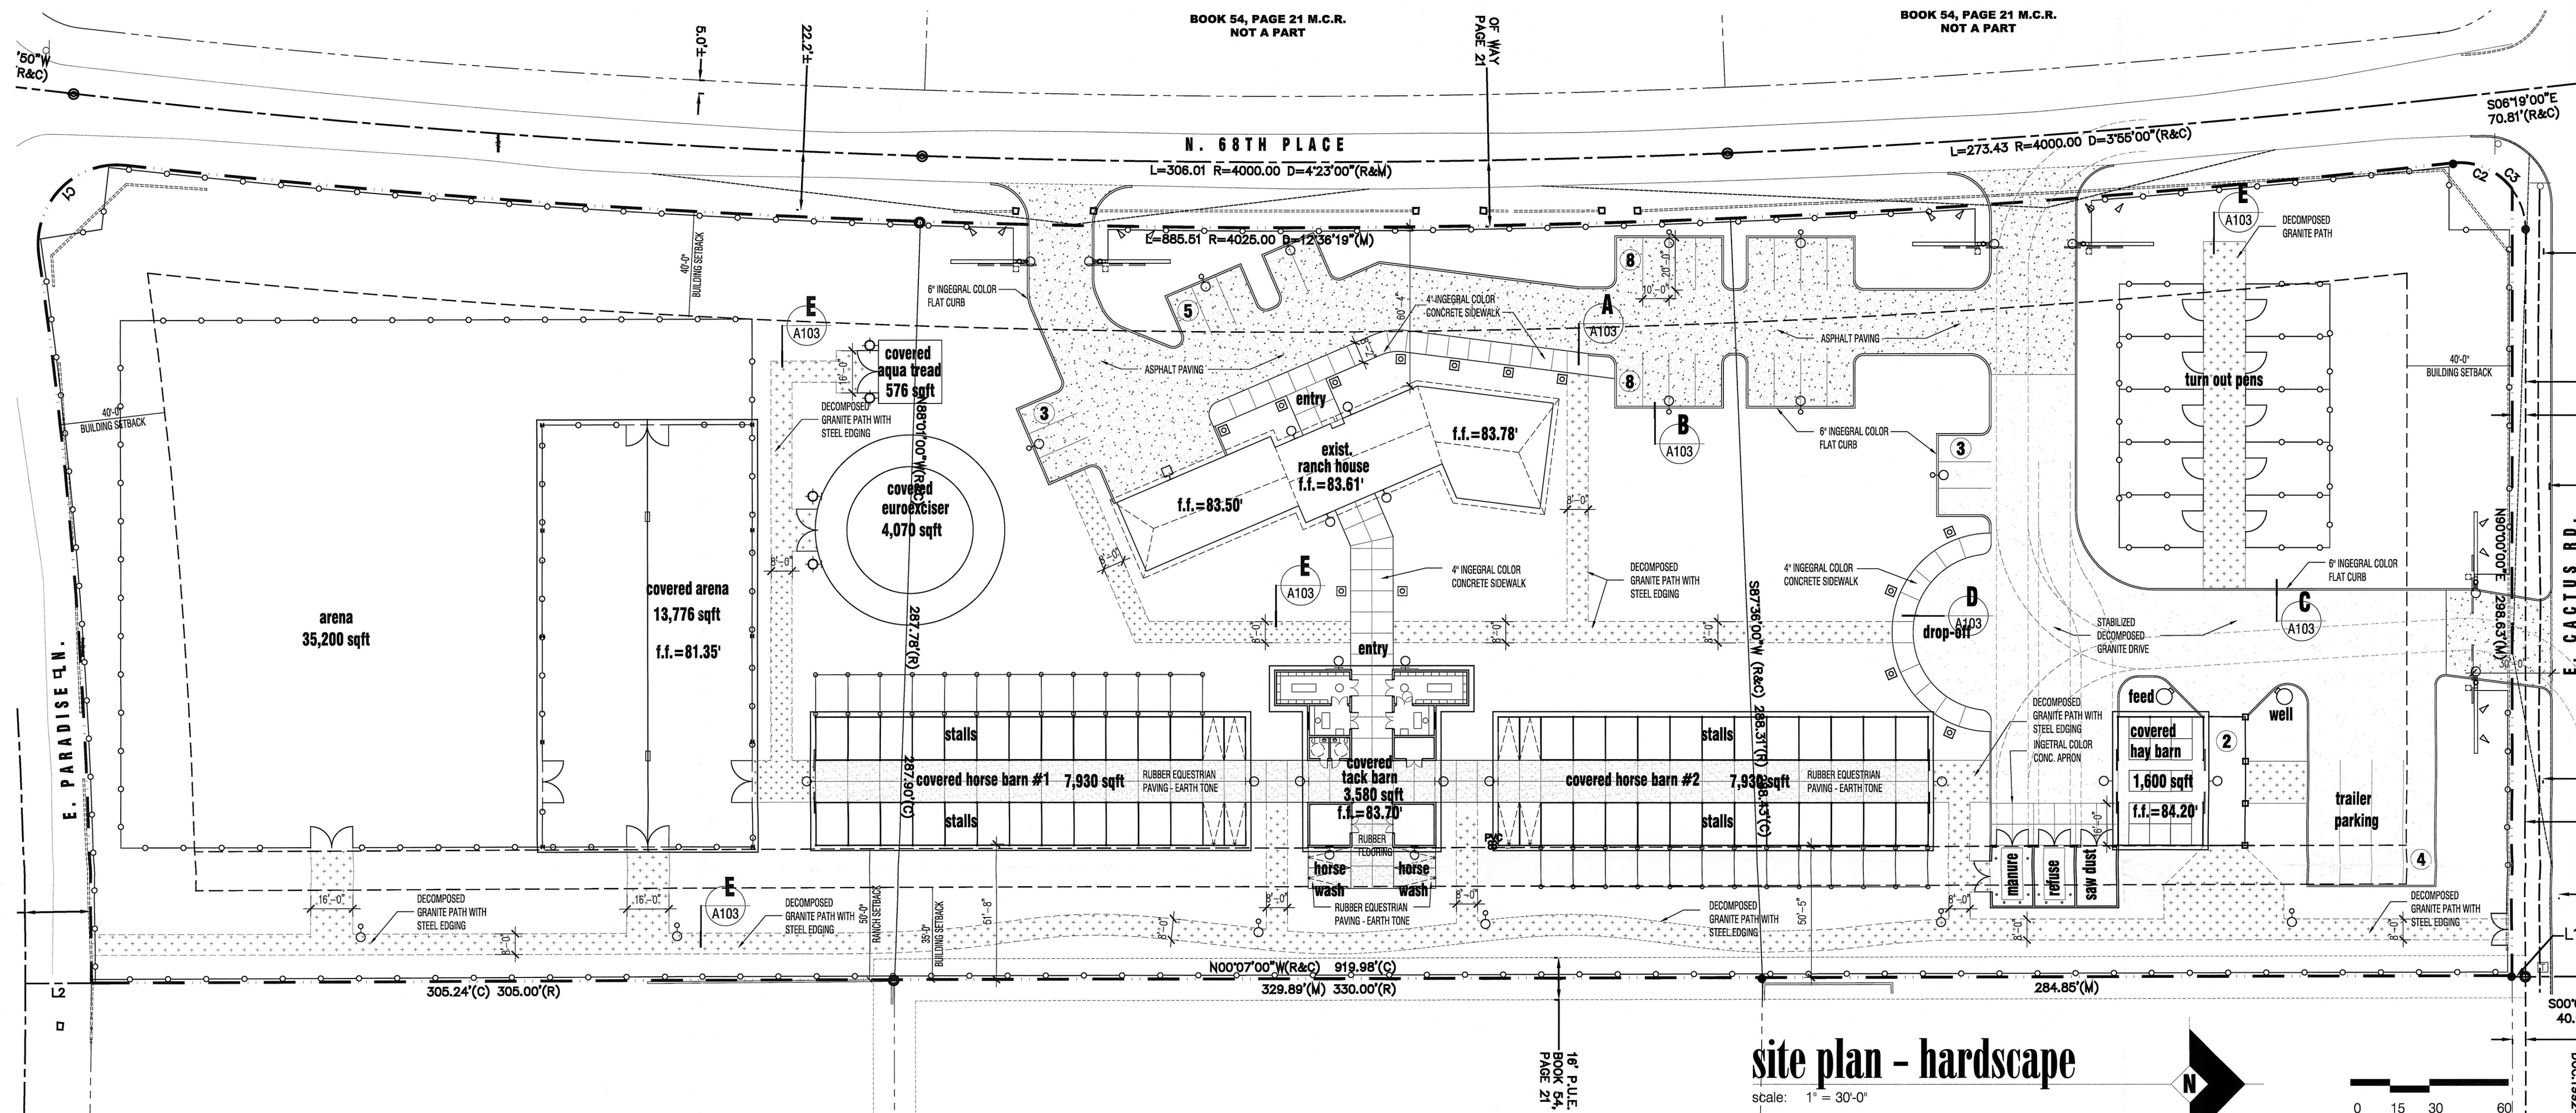

NAJAFI RANCH

525 BOYNTON CANYON ROAD

Douglas Fredrikson Architects
727 east bethany home road, d-123
phoenix, arizona 85014
602.277.1625

these documents are instruments of service of the authors and are for use on this project only. they are prepared for use in conjunction with the authors interpretations, observations, decisions, and administration as described in this set of documents. without which desired result can not be assured. alteration, reproduction, or use in part or in whole, for other purposes without the authors written consent may violate existing legal statutes.

13100

site plan

issue date


10.25.2015

revisions


a

102


4-UP-2013
11/12/15

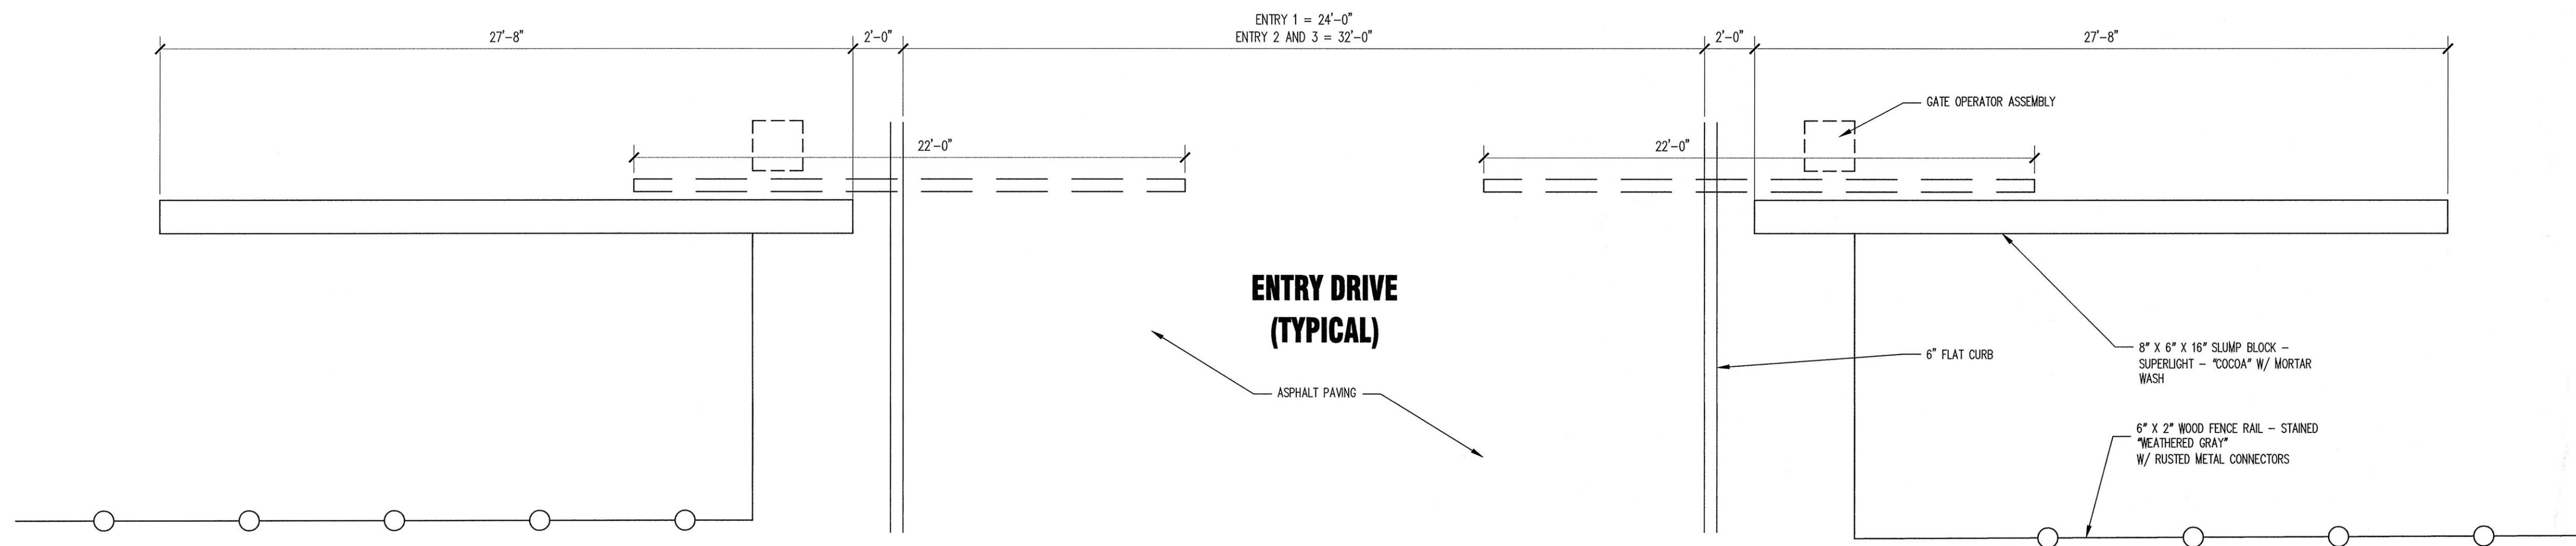


1 entry and perimeter fence plan
1/4" = 1'-0"

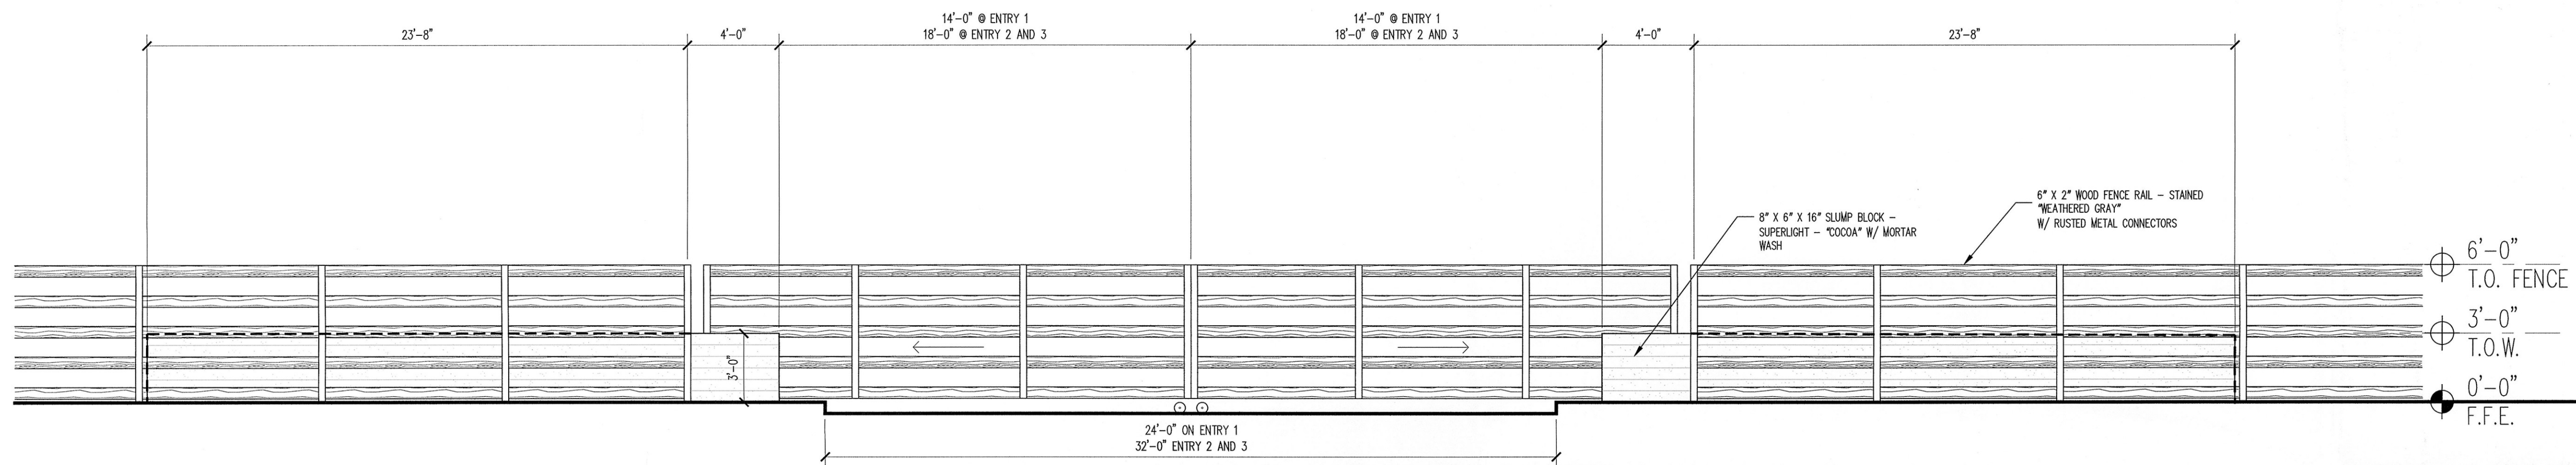

2 entry and perimeter fence elevation
1/4" = 1'-0"

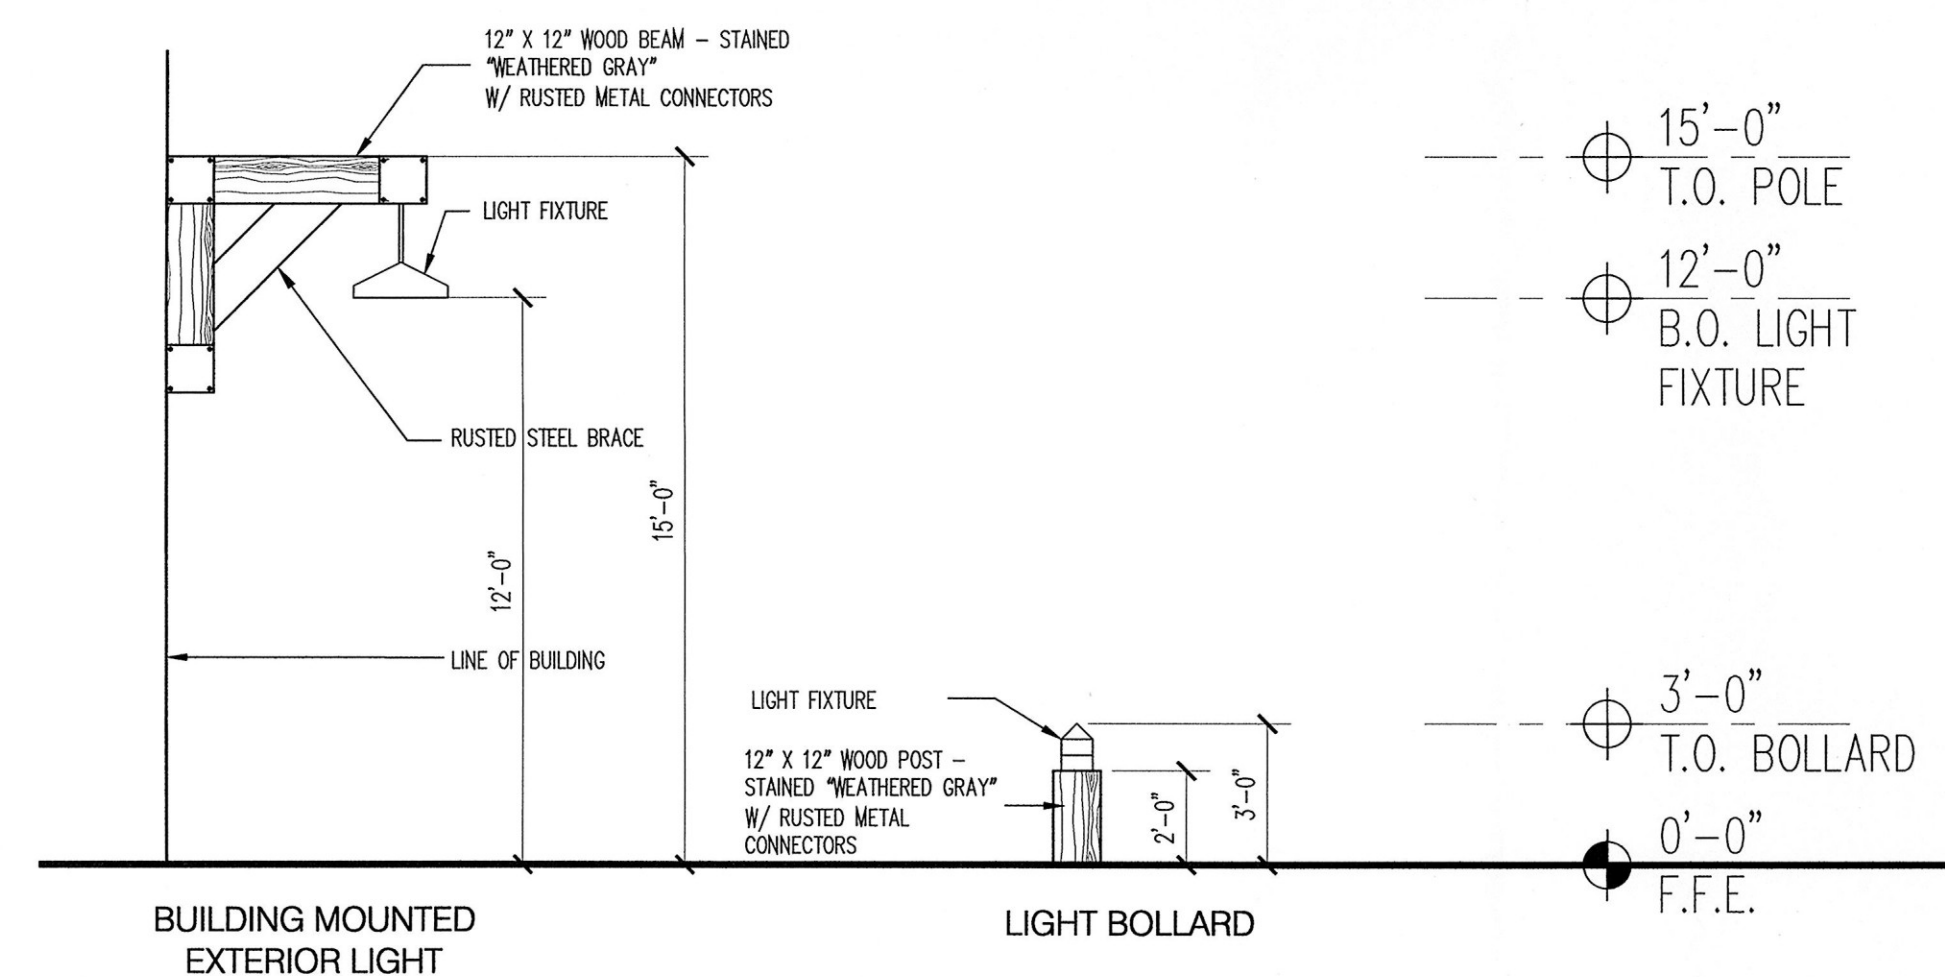

3 exterior lighting fixtures
1/4" = 1'-0"

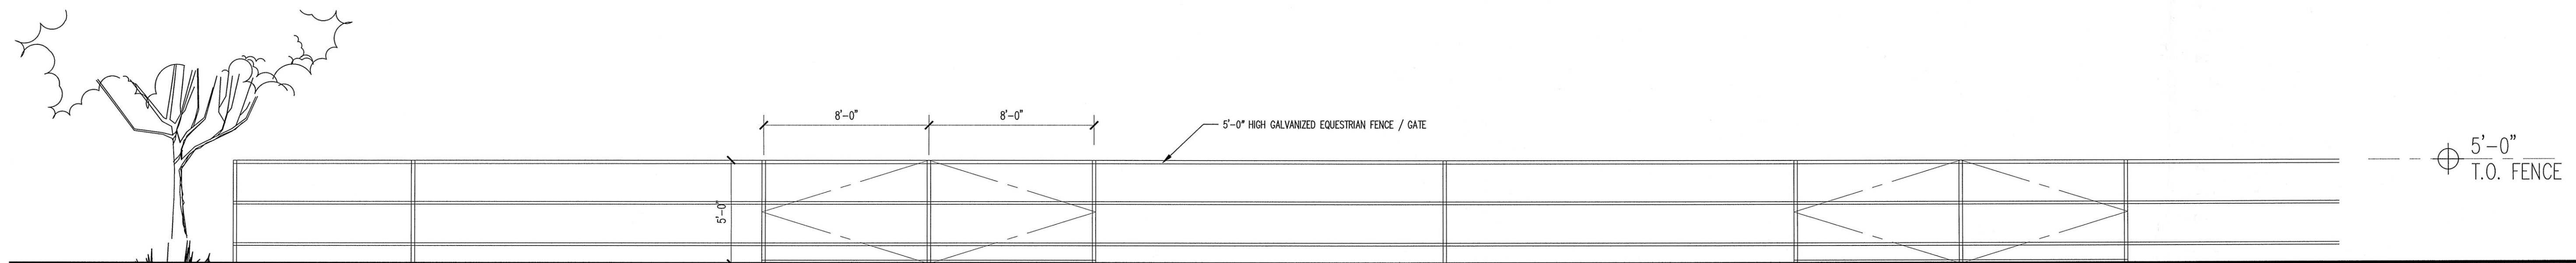

4 horse corral / arena fence
1/4" = 1'-0"



NAJAFI RANCH

525 BOYNTON CANYON ROAD



Douglas Fredrikson Architects
727 east bethany home road, d-123
phoenix, arizona 85014
602.277.1625


these documents are instruments of service of the authors and are for use on this project only. they are prepared for use in conjunction with the authors interpretations, observations, decisions, and administration as described in sds doc sds01, without which desired result can not be assured. alteration, reproduction, or use in part or in whole, for other purposes without the authors written consent may violate existing legal statutes.

13100


site plan
issue date

10.25.2015
revisions


a
103

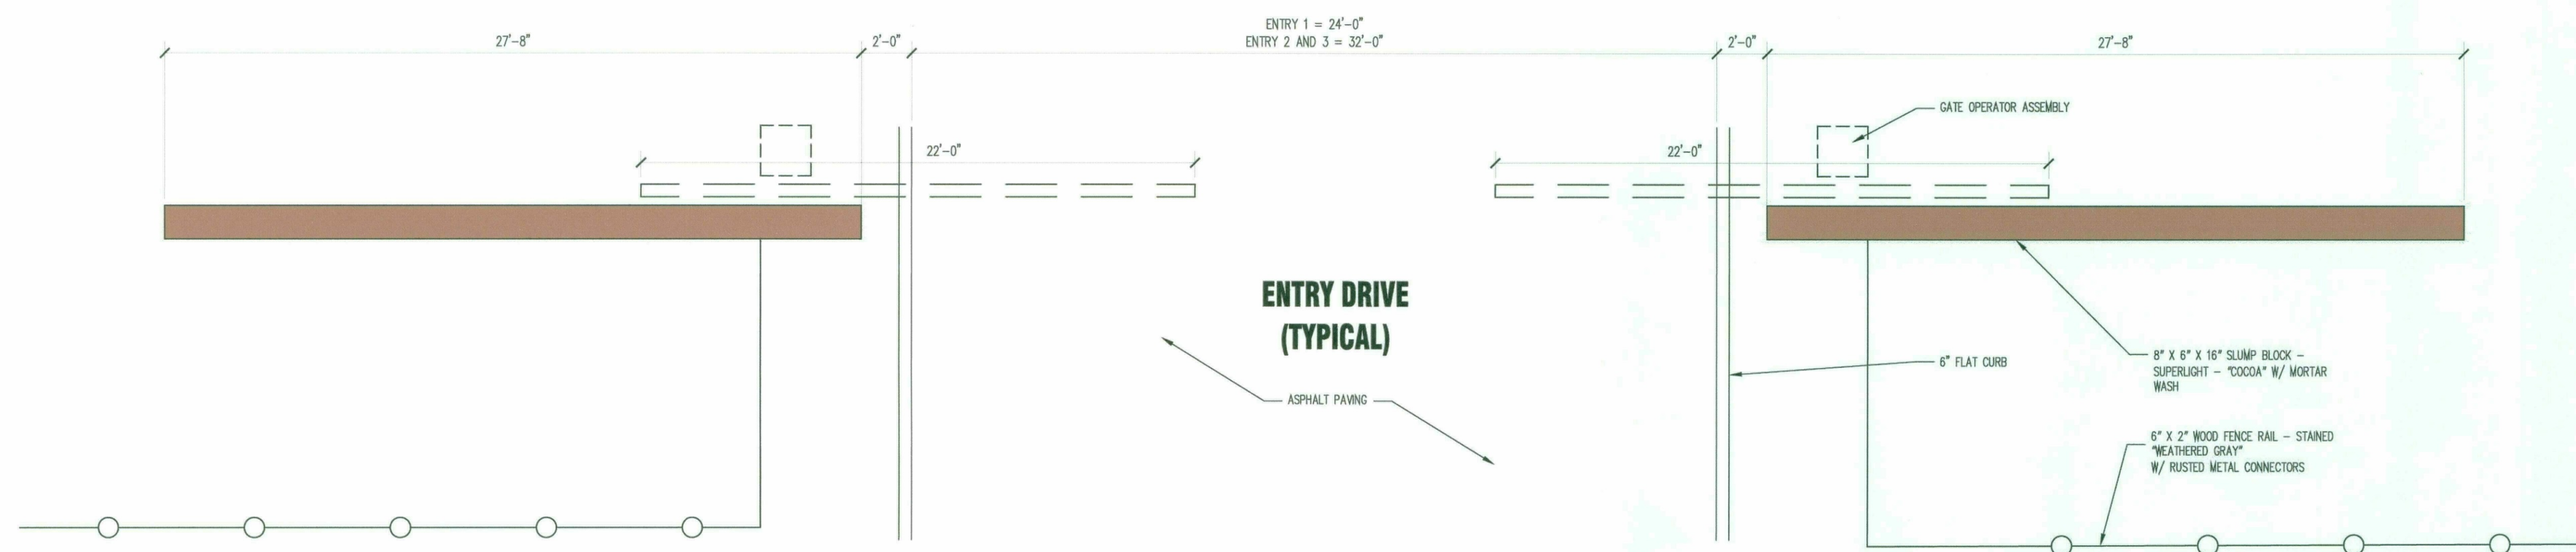


1 entry and perimeter fence plan
1/4" = 1'-0"

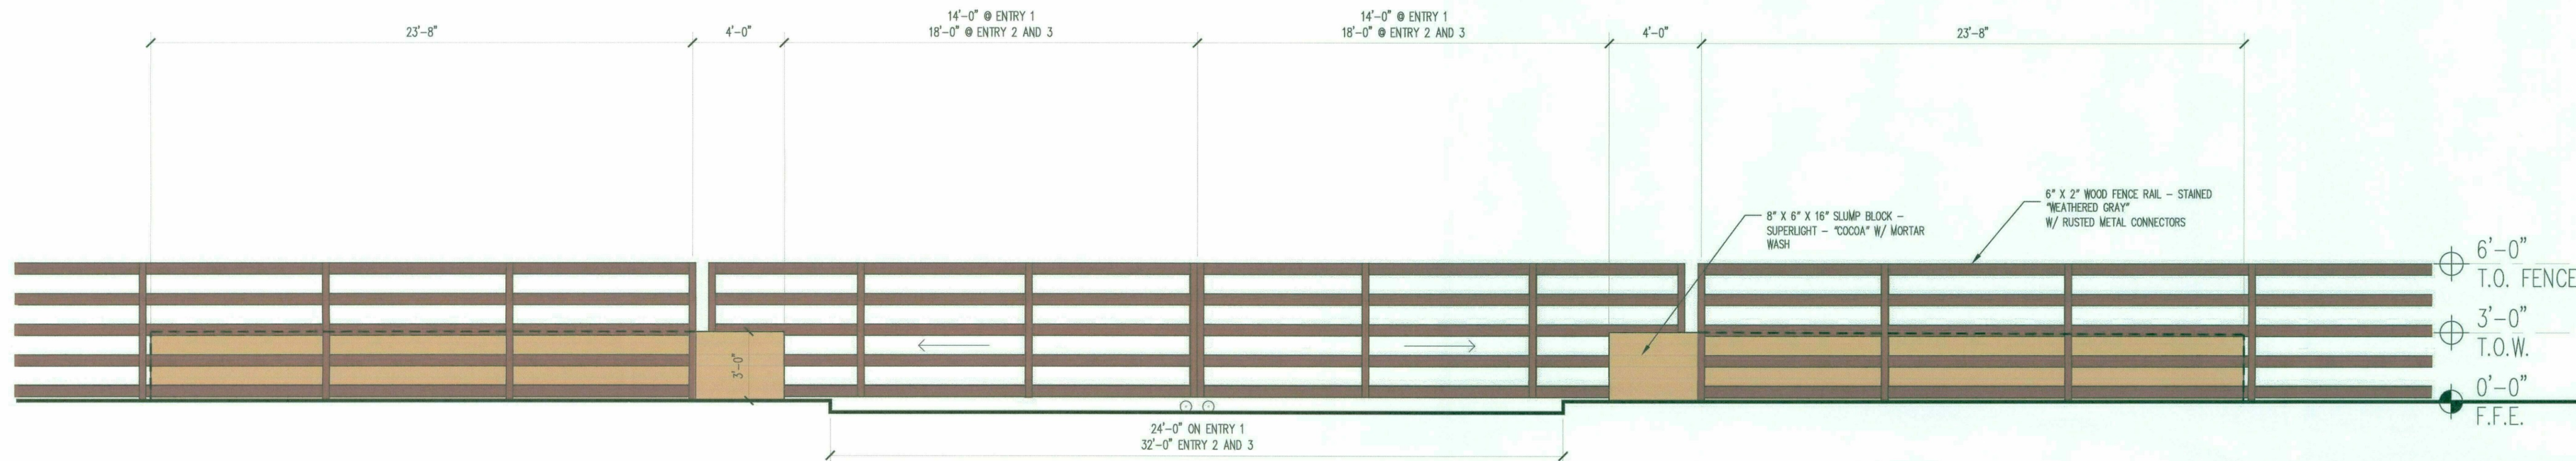

2 entry and perimeter fence elevation
1/4" = 1'-0"

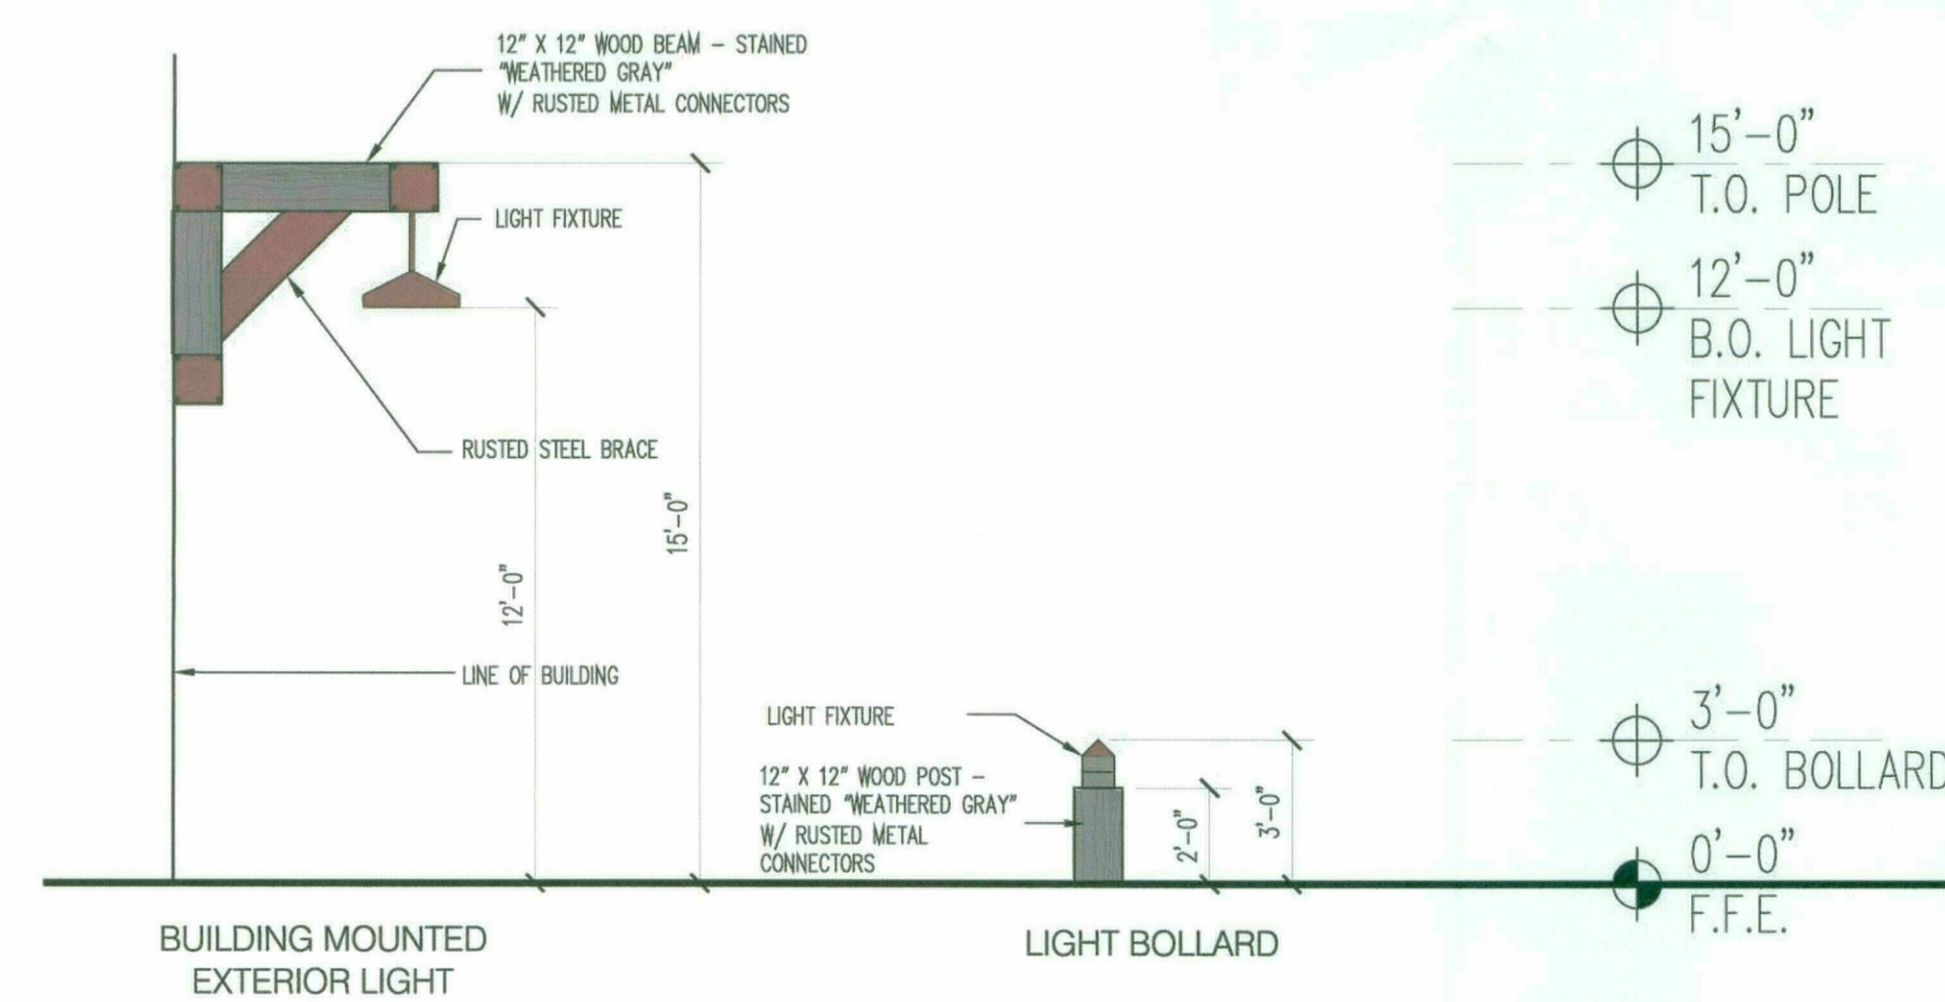


3 exterior lighting fixtures
1/4" = 1'-0"

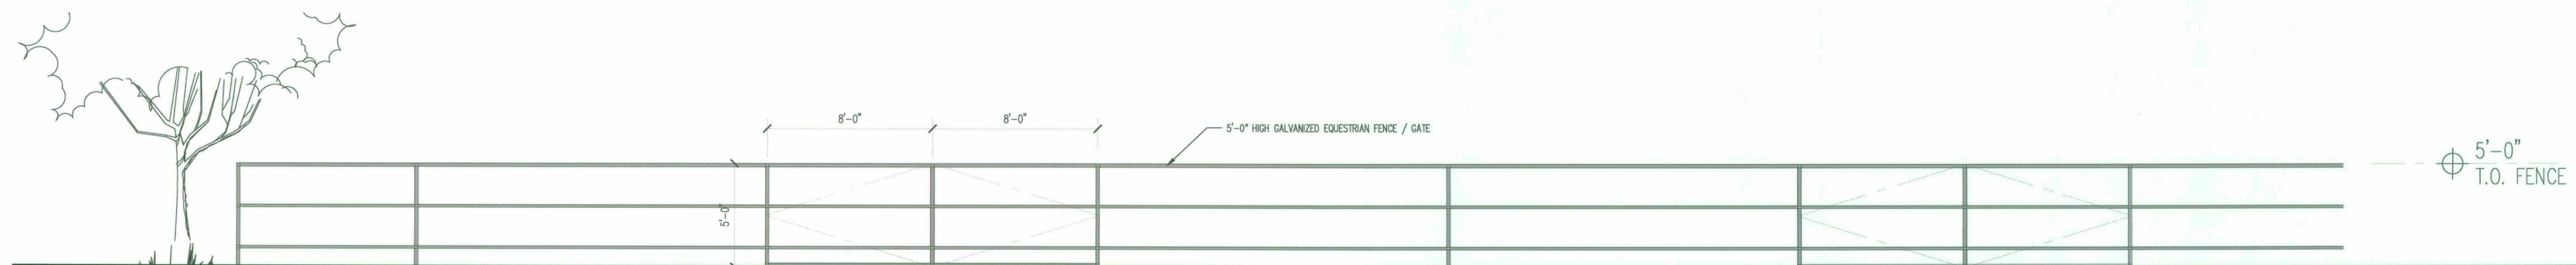

4 horse corral / arena fence
1/4" = 1'-0"



NAJAFI RANCH
525 BOYNTON CANYON ROAD

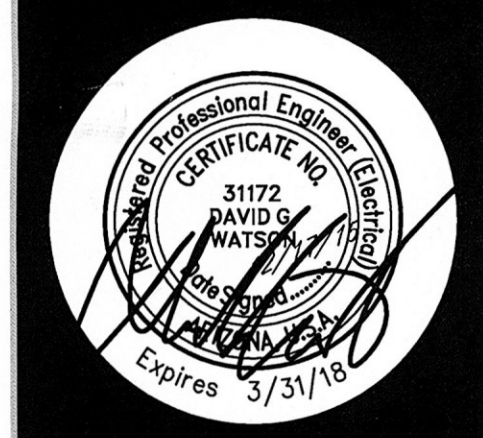

Douglas Fredrikson Architects
727 east bethany home road, d-123
phoenix, arizona 85014
602.277.1625

these documents are instruments of service of the authors and are for use on this project only. they are prepared for use in conjunction with the authors interpretations, observations, decisions, and administration as described in aia doc a191, without which desired result can not be assured. alteration, reproduction, or use in part or in whole, for other purposes without the authors written consent may violate existing legal statutes.

13100

electrical site lighting plan

issue date

10.25.2015

revisions


City Comments 12.17.15

e
101

LIGHT FIXTURE SCHEDULE


MARK	DESCRIPTION	MFR.	CATALOG #	VOLT.	LAMPS # TYPE	REMARKS
B	PENDANT MTD LED	BARN LIGHT	SW-B13650 S124	120	1 GU24 BI-PIN 18W	12'-0" FIXTURE HEIGHT ABOVE FINISHED GRADE
C	LED WALL SCONCE	BARN LIGHT	WWHA8-PC 600	120	-	MOUNT AT 6'-6"
D	LED AREA LIGHT	BARN LIGHT	WWHA10-PC 600	120	-	MOUNT AT EDGE
F	LED WALL SCONCE	BARN LIGHT	WWHA10-PC 600	120	-	-
G	LENSED LED SECURITY LIGHT	COLUMBIA	LXEW430HCP WEUDWH	120	- LED	-
H	LED WALL SCONCE	BARN LIGHT	WHA8-PC-100	120	-	-
K	LED LANDSCAPE LIGHT	BK	DS LED E22 MFL A9 BLW 12 A 360SL	120	-	AIM AWAY FROM PROPERTY LINE

* NOTE:
FLUORESCENT FIXTURES SHALL CONTAIN A BALLAST DISCONNECTING MEANS IN ACCORDANCE WITH N.E.C. ARTICLE 410.130(G).

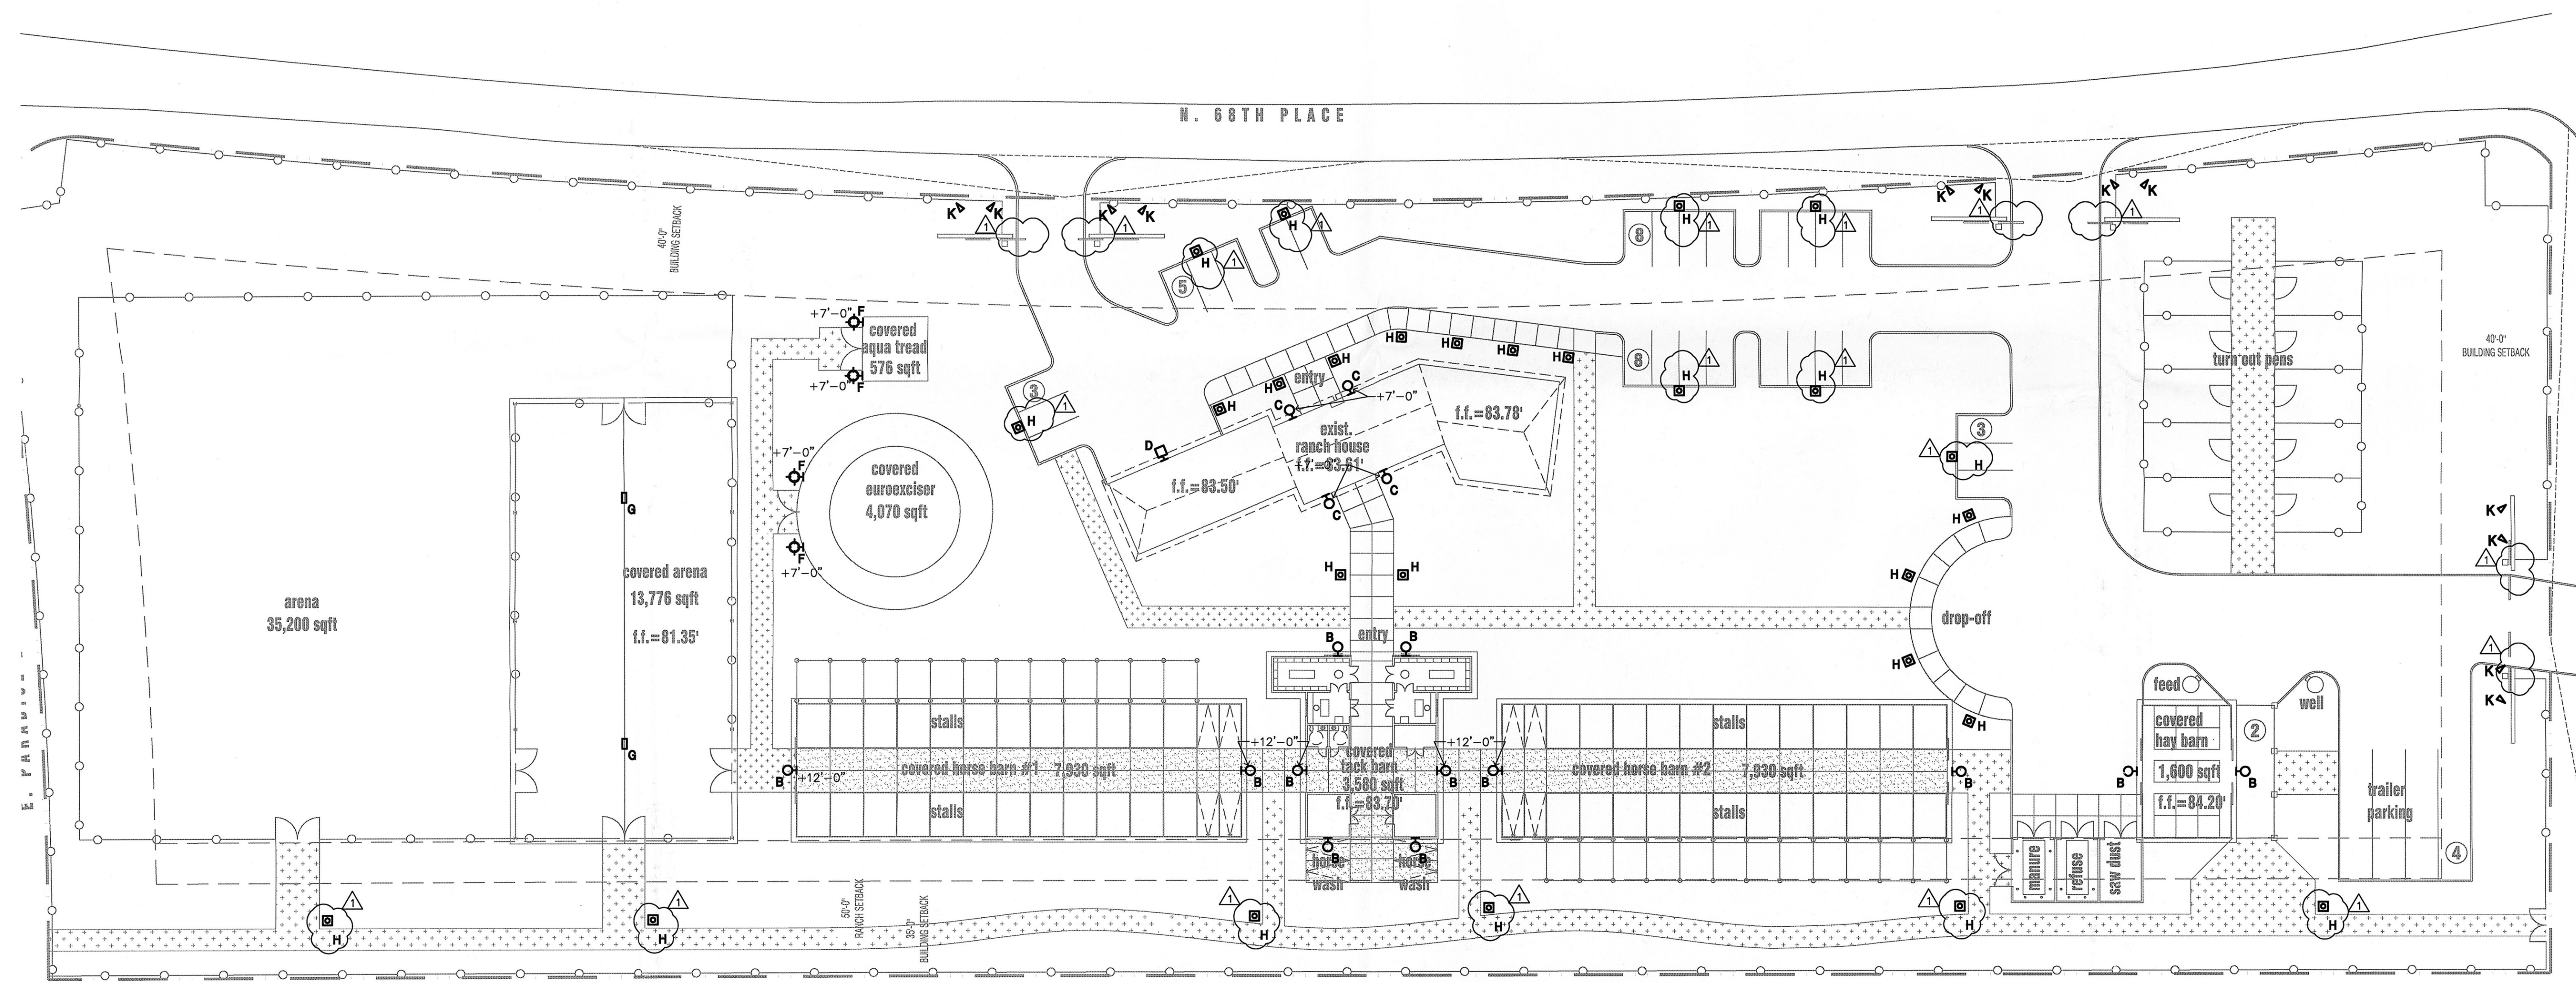

site lighting plan

scale: 1" = 30'-0"

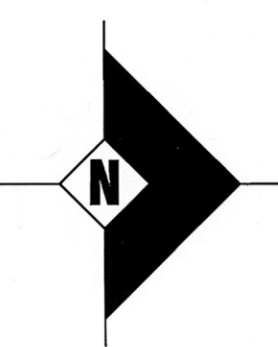


0 15 30 60

Job No. 15231
David Watson, P.E.
davew@mwgroup.com
e 480.731.5050 f 480.731.5353
2001 W Alameda Drive, Suite 102 Tempe, AZ 85282
mw engineering, llc
Electrical Consulting Engineering Group



NAJAFI RANCH

525 BOYNTON CANYON ROAD

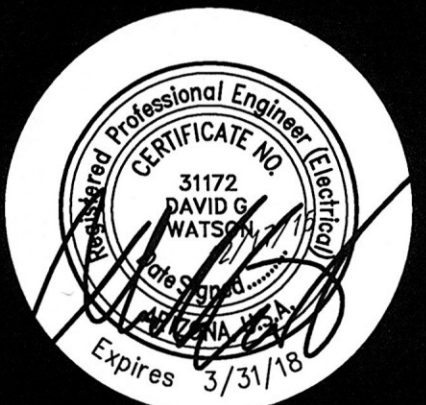

Douglas Fredrikson Architects
727 east bethany home road, d-123
phoenix, arizona 85014
602.277.1625

these documents are instruments of service of the authors and are for use on this project only. they are prepared for use in conjunction with the author's interpretations, observations, decisions, and administration as described in aia doc a301, without which desired result can not be assured. alteration, reproduction, or use in part or in whole, for other purposes without the authors written consent may violate existing legal statutes.

13100

photometrics - post curfew

issue date

10.25.2015


revisions

City Comments 12.17.15




Luminaire Schedule						
Label	TEST	Symbol	Description	MTG HEIGHT	MOUNTING	Lum. Watts Qty
B	11773-G	●	BARN LT - S-WHB17-650-5724-650-LED-LMH2-1250	12' MTG HT.	SINGLE	21 12
C	11773-G	●	BARN LT - W-WHA16-PC-600-LED-LMH2-850LU	6.6' MTG HT.	SINGLE	10 4
D	11773-G	●	BARN LT - W-WHA16-PC-600-LED-LMH2-1250	12' MTG HT.	SINGLE	21 1
F	11773-G	●	BARN LT - W-WHA16-PC-600-LED-LMH2-1250	12' MTG HT.	SINGLE	21 4
H	11773-G	●	BARN LT - X-WHA16-PC-600-LED-LMH2-850LU	2.5' MTG HT.	SINGLE	10 27
K	ITL63766	●	DS-LED-e23-MFL-13; AR-LED-TR-e23-MFL-13-C; AR	6 INCH MTG HT.	SINGLE	8.5 12

Calculation Summary							
Label	CalcType	Units	Avg	Max	Min	Avg/Min	Max/Min
PERIMETER 6' ABOVE GRADE	Illuminance	Fc	0.00	0.0	0.0	N.A.	N.A.
SITE - POSTCURFEW	Illuminance	Fc	0.04	9.6	0.0	N.A.	N.A.

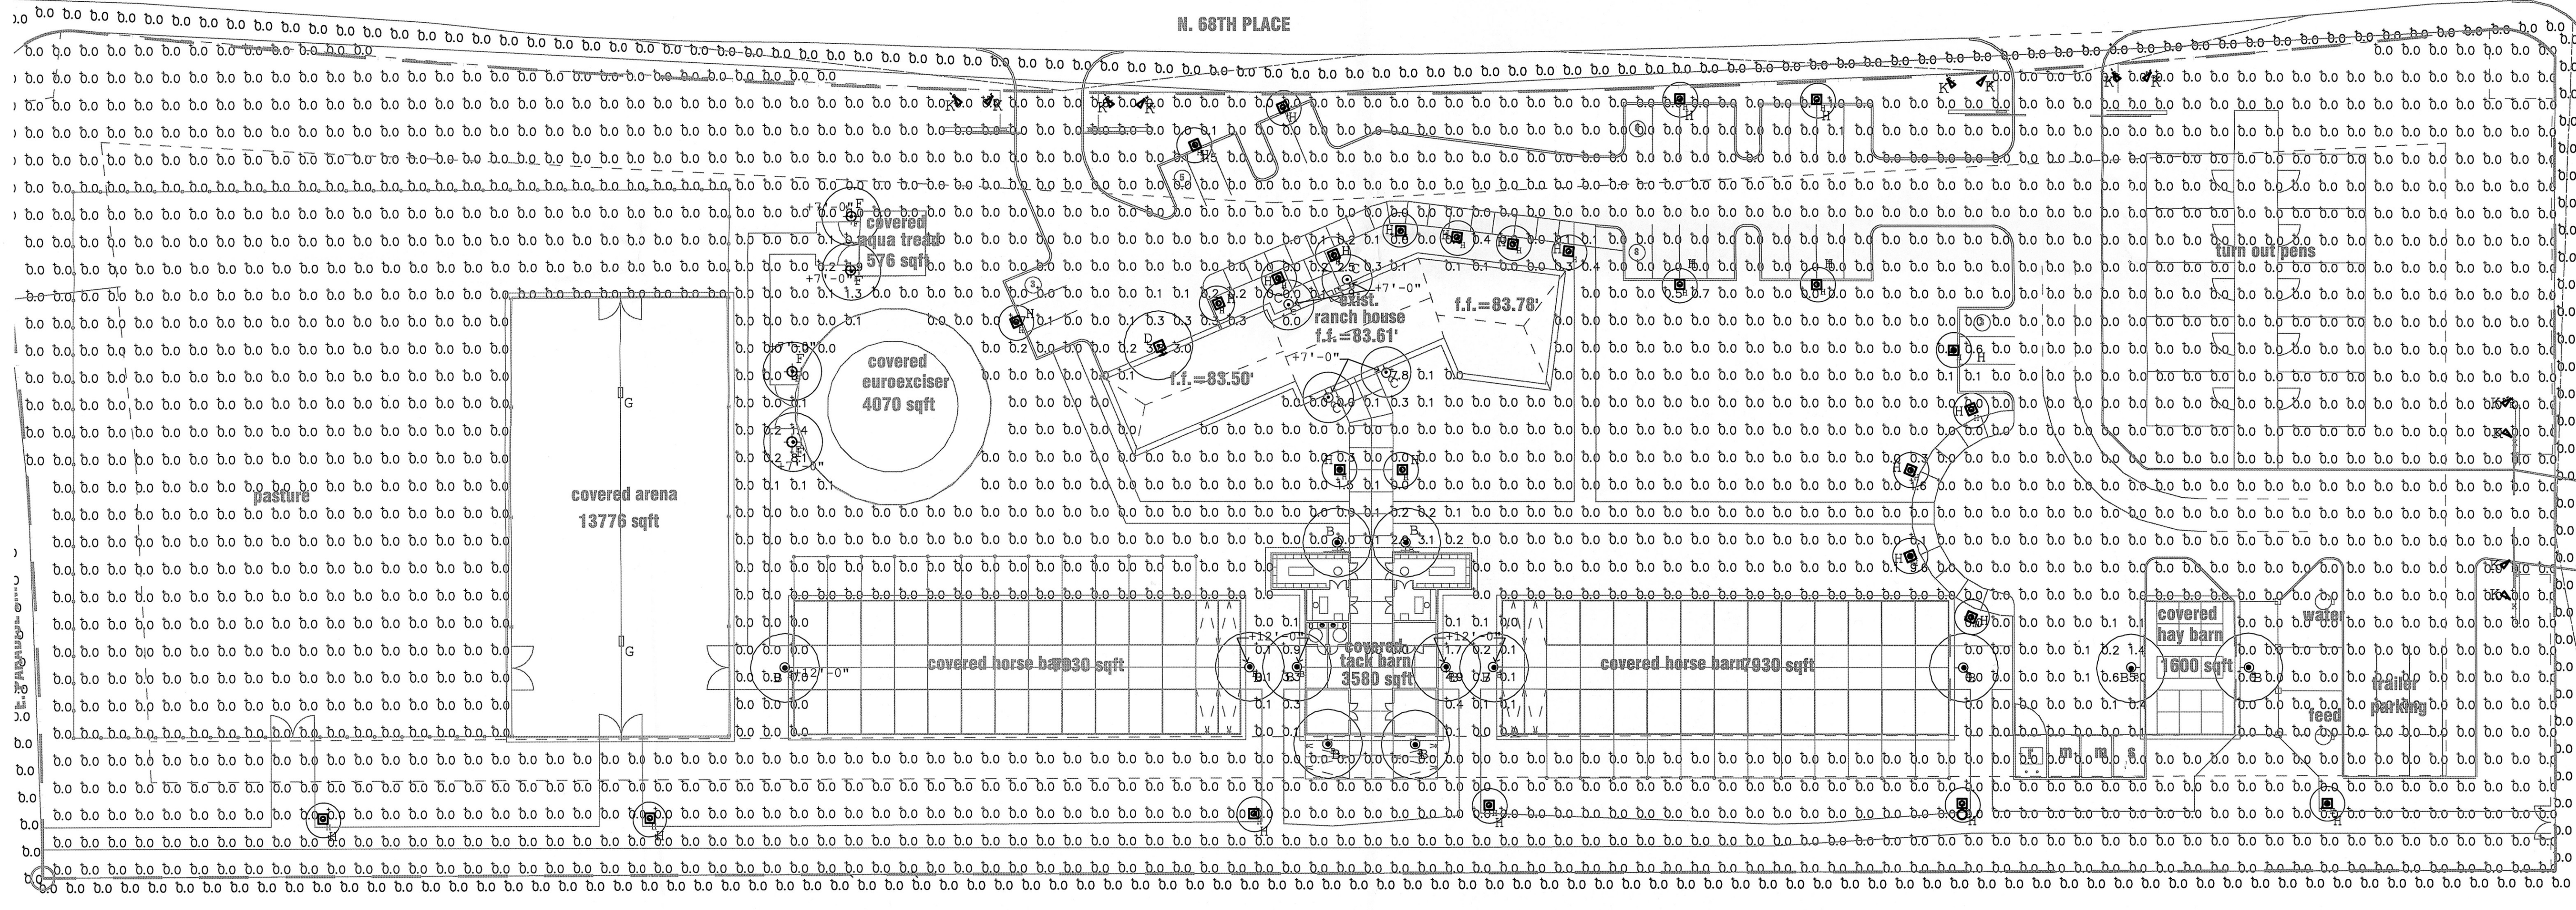

photometrics post curfew

scale: 1" = 30'-0"

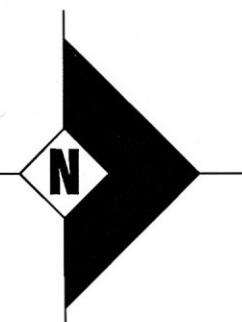


mw engineering, llc
Electrical Consulting Engineering Group

Joh No. 15231
David Watson, P.E.
dave@mwgroup.com
o 480.731.5050 f 480.731.5263
2001 W Alameda Drive, Suite 102 Tempe, AZ 85282


Luminaire Schedule						
Label	(TEST)	Symbol	Description	MTG HEIGHT	MOUNTING	Lum. Watts Qty
B	11773-G	●	BARN LT - S-WHAB17-450-3124-650-LED-LMH2-1250	12' MTG HT.	SINGLE	21 12
C	11773-G	●	BARN LT - W-WHAB-PC-600-LED-LMH2-850LU	6.5' MTG HT.	SINGLE	10 4
D	11773-G	●	BARN LT - W-WHAB10-PC-600-LED-LMH2-1250	12' MTG HT.	SINGLE	21 1
F	11773-G	●	BARN LT - W-WHAB10-PC-600-LED-LMH2-1250	12' MTG HT.	SINGLE	21 4
H	11773-G	●	BARN LT - X-WHAB-PC-600-LED-LMH2-850LU	2.5' MTG HT.	SINGLE	10 27
K	TL63766	●	DS-LED-623-MFC-13; AR-LED-TR-623-MFC-13-C; AR	6 INCH MTG HT.	SINGLE	8.5 12

Calculation Summary						
Label	CalcType	Units	Avg	Max	Min	Avg/Min Max/Min
PERIMETER 6' ABOVE GRADE	Illuminance	Fc	0.00	0.0	0.0	N.A. N.A.
SITE - PRECURFEW	Illuminance	Fc	0.10	14.9	0.0	N.A. N.A.

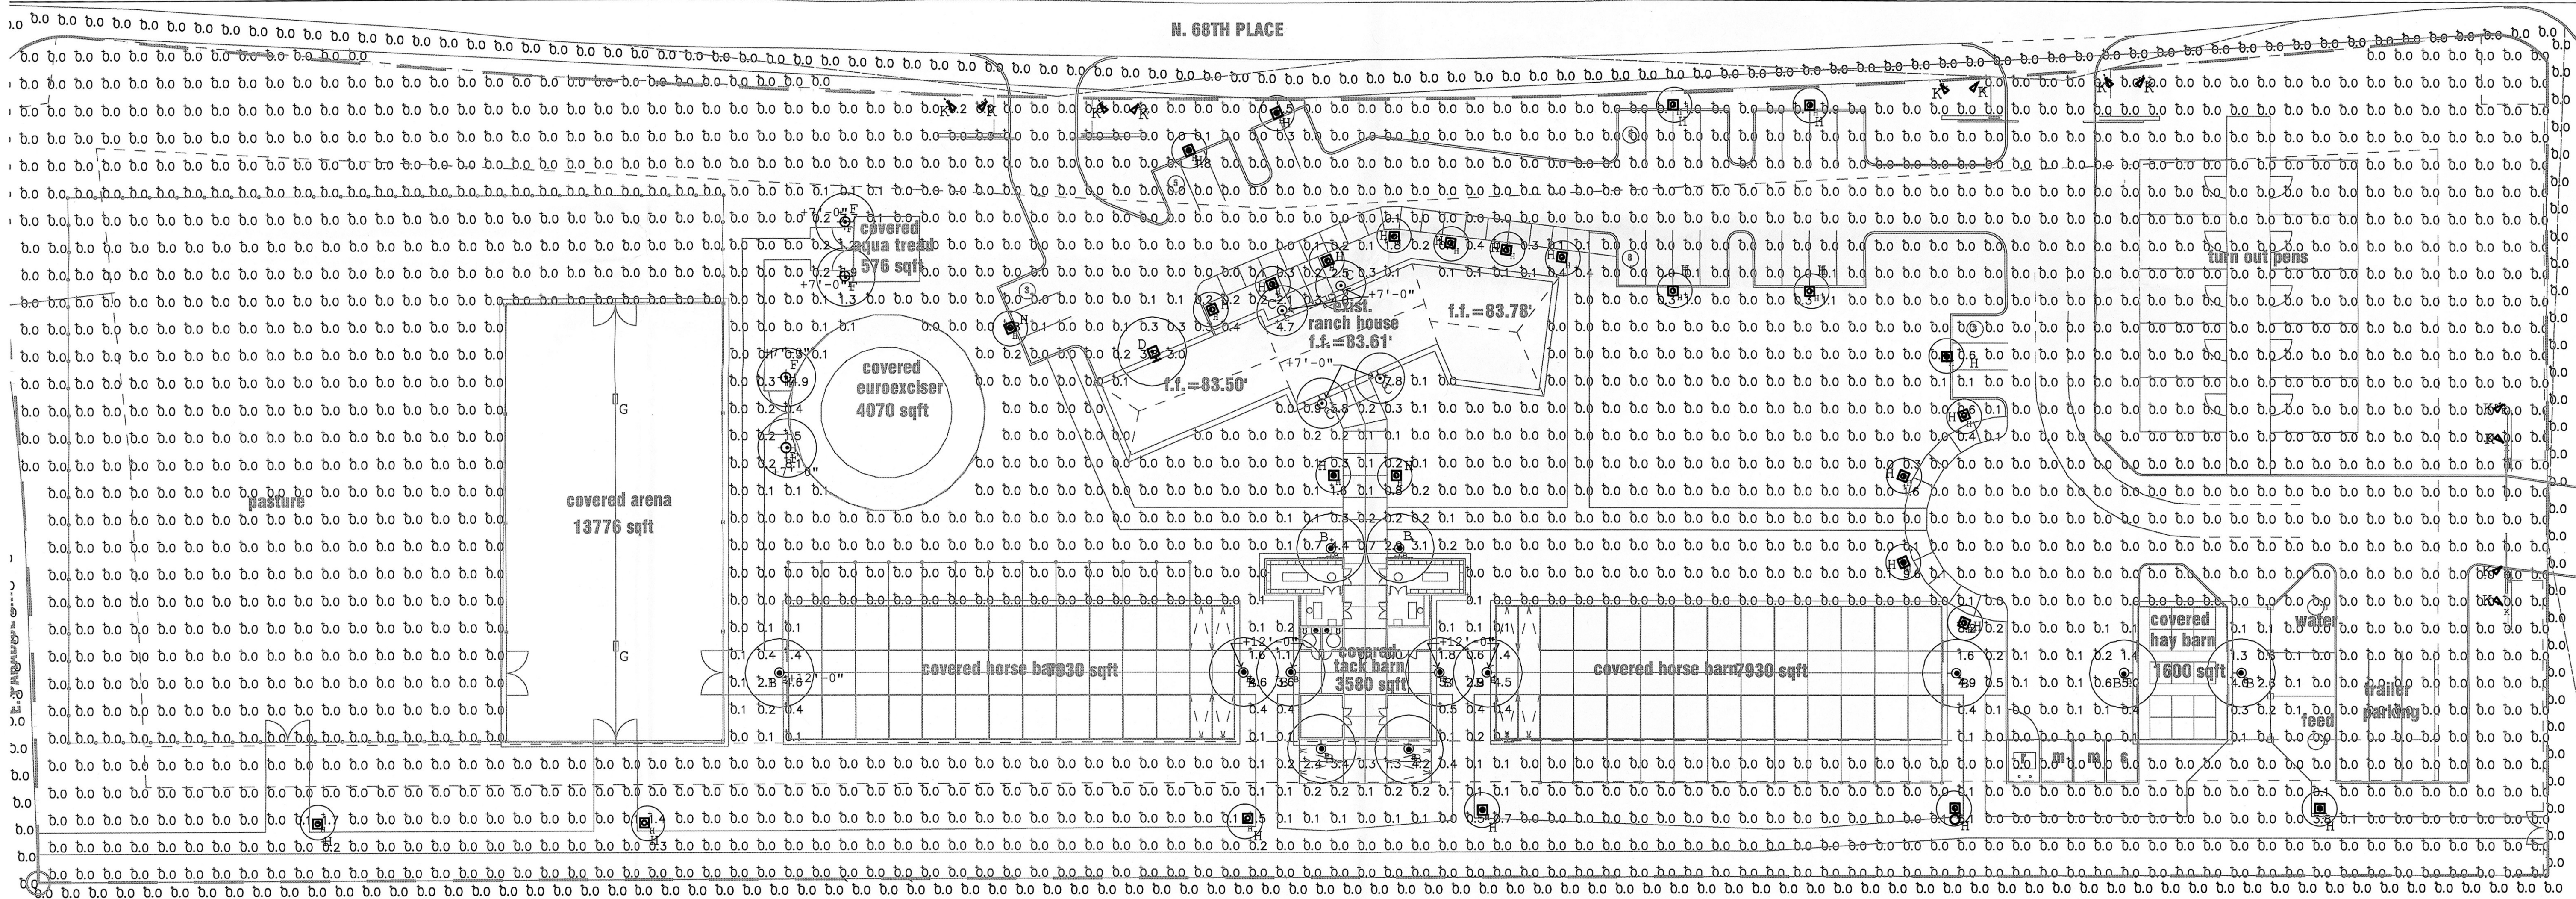

photometrics pre curfew

 scale: 1" = 30'-0"





Job No. 15231
David Watson, P.E.
dave@mwengr.com
o. 480.731.5050 f. 480.731.5353
2001 W Alameda Drive, Suite 102 Tempe, AZ 85282

mw engineering, llc
 Electrical Consulting Engineering Group



NAJAFI RANCH

525 BOYNTON CANYON ROAD



Douglas Fredrikson Architects
 727 east bethany home road, d-123
 phoenix, arizona 85014
 602.277.1625

these documents are instruments of service of the authors and are for use on this project only; they are prepared for use in conjunction with the authors interpretations, observations, decisions, and administration as described in aia doc a201, without which desired result can not be assured; alteration, reproduction, or use in part or in whole, for other purposes without the authors written consent may violate existing legal statutes.

13100

photometrics - pre curfew

issue date

10.25.2015

revisions

City Comments 12.17.15



ELECTRICAL SYSTEM SPECIFICATIONS - DIVISION 16000

1. GENERAL CONDITIONS
- The General Provisions of the Contract, including the Conditions of the Contract (General, Supplementary and other Conditions) and Division 1 – General Requirements as appropriate, apply to the work specified in this Section.
2. SCOPE OF WORK
- The work included under this section consists of furnishing all materials, equipment, and labor and the performing of all functions, except as otherwise specified herein or shown on the drawings to be performed by others, for the installation and placing into operation of a complete electrical system as specified and shown on the drawings.
3. GENERAL DESCRIPTION
- 3.1 The work in general shall consist of, but is not necessarily limited to the following.
- 3.1.1 Furnishing and installing all fixtures with lamps as indicated on the drawings and as specified herein unless noted.
- 3.1.2 Furnishing and installing all electrical work, panels, service, conduit, wiring, etc., for all outlets and equipment.
- 3.1.3 Furnishing and installing all telephone outlets, conduits with pull strings and telephone mounting boards including conduit from telephone mounting board to the building entrance as indicated on the plan.
- 3.1.4 Furnishing and installing a complete Fire Alarm system as indicated on plans.
- 3.1.5 Include \$ _____ hundred dollars) allowance for power and telephone company utility service charges. Difference between actual cost and allowance to be credited or billed to the Owner.
- 3.1.6 Furnishing and installing all motor starters and control components, not specifically specified to be furnished in accordance with other sections of the specifications.
- 3.1.7 Furnishing and installing all power and wiring except that which is pre-wired in factory assembled equipment.
- 3.1.8 Installing all LINE VOLTAGE mechanical control wiring and associated controls which are furnished by the Mechanical Contractor (low voltage control wiring and controls shall be furnished and installed by the Mechanical Contractor).
- 3.1.9 Painting work as described under other sections of these specifications. Clean and prepare all surfaces ready for painting.
- 3.1.10 Provide temporary construction power as outlined below. This service shall be maintained throughout the entire job as the work progresses. Provide outlets at convenient points and in sufficient numbers so that no extension cord over 50 feet in length is required to reach any work point. Maintain general lighting in corridors, stairs, basement and other areas not receiving sufficient daylight required for safety. Remove temporary work as rapidly as required for or allowed by installation of permanent work.
- 3.1.11 Certain items of work by other trades will be necessary for the completion of work under this division. Cooperate with other trades and arrange for these items to be performed in orderly course.
- 3.1.12 This Contractor shall review the mechanical control requirements as specified and shown on the drawings and shall furnish and install all necessary conduit, wiring, boxes, protective devices, switches, etc., for the completion and proper operation of the system.
- 3.1.13 Review all drawings and all specifications for each section of work. Unless specifically noted otherwise, herein or elsewhere, furnish and install items of any electrical nature required for completion of work for other trades, whether or not same is shown or noted in this or other sections.
4. REGULATIONS AND CODES
- The Contractor must comply with all state, municipal and federal safety laws, construction codes, ordinances and regulations relating to building and public health and safety. In addition, comply with rules and regulations of the State Fire Protection Code. Fire protection material must bear the Fire Underwriters Laboratories label.
5. GENERAL REQUIREMENTS
- 5.1 The Contractor shall examine the premises and satisfy himself of existing conditions under which he will be obligated to operate in performing his part of the work or that will in any manner affect the work under the contract. The Contractor shall cooperate with other trades so that the installations of all equipment may be properly coordinated.
- 5.2 All equipment furnished shall fit the space available, with connection, etc., in the required locations and with adequate space for operating and servicing. The drawings are generally diagrammatic and indicate the manner and method of the installation, while the specifications and fixture list denote the type and quality of material and workmanship to be used. Where a conflict exists between the drawings and the specifications, the Contractor shall promptly notify the Architect/Engineer whose decision shall be final. No allowance will be made subsequently in this connection in behalf of the Contractor after award of the contract.

6. EQUIPMENT AND MATERIAL
- 6.1 All materials furnished under this contract shall be new (except as noted), free from defects of any character, shall conform with the standards of the Underwriters Laboratories, Inc. (U.L.) (or other nationally recognized Laboratory), in every case where such a standard has been established and shall be so labeled. It is the intention of these specifications to indicate a standard of quality for all materials incorporated in this work, and where materials are not specified herein and are required to complete the electrical installation, these materials shall be of first quality for use intended. Manufacturers of similar quality products will be considered unless the specifications or drawings indicate otherwise.
- 6.2 Materials shall be suitable for intended use and location. Unless otherwise shown use NEMA-1 for interior areas and NEMA-3R for exterior areas.
- 6.3 The Architect/Engineer decision as to equal in grade and quality shall rule and be final for all electrical materials incorporated in this work. Where two or more similar type items are furnished, all shall be of the same manufacturer (e.g., all disconnect switches shall be of the same manufacturer) unless otherwise noted herein or shown on the drawings. All material and installation methods used shall be in accordance with the latest and approved electrical and mechanical engineering practices.
7. SERVICE ENTRANCE EQUIPMENT
- 7.1 Service entrance equipment shall be in accordance with the requirements of the municipal governing body and serving utility. Shop drawings shall be submitted to the serving utility for written approval before ordering equipment.
- 7.2 Label equipment and each individual overcurrent device per Section 16000.22.
- 7.3 Approved manufacturers are: Sun Valley, Square D, Cutler-Hammer, Siemens/ITE, General Electric
8. PANELBOARDS
- 8.1 Each panel shall be provided with door lock and two keys, all keyed alike. Each panel shall be provided with typewritten sheet installed on door identifying the use of each branch circuit. Panels shall have bussing as indicated on the drawings.
- 8.2 Label equipment per Section 16000.22
- 8.3 Approved manufacturers are: Square D, Cutler-Hammer, Siemens/ITE, General Electric
9. STARTERS
- 9.1 All motor starters shall be furnished under this section of the specifications unless an integral part of equipment or noted as furnished with equipment specified under other sections of these specifications.
- 9.2 Separately mounted motor starters shall be across-the-line combination magnetic with 120V coils, fused disconnect contactors, additional auxiliary contact for interlocking of controls. Provide pushbutton or selector switch in cover. Switchboard mounted starters shall be magnetic with 120V coils and additional auxiliary contacts as required for interlocking of controls. Starters shall have an integral control circuit transformer or separate 120V control with control circuit disconnect switch in cover.
- 9.3 Manual starters shall be horsepower, voltage and phase rated with overload protection and green "on" pilot light. Surface mounted unless noted otherwise.
- 9.4 All starters shall have overload protection in all phase lines. Furnish and install the proper size overload heater elements determined from full load nameplate readings on motors and compensation for ambient temperature in all starters whether they be furnished under this Section or other Sections.
- 9.5 Label per Section 16000.22
- 9.6 Approved manufacturers are: Square D
10. TRANSFORMERS
- 10.1 Transformers shall be dry type, with voltage ratings as indicated on plans. Transformers shall be rated for full load operation at a maximum 150 degree centigrade rise above a 40 degree centigrade ambient or as otherwise noted on drawings. Provide at least (4) 2 1/2 percent taps, two above normal and two below normal and have a sound rating not to exceed NEMA standards. Special "K" factor ratings as noted.
- 10.2 Submit complete transformer data with shop drawings for approval. The data shall include efficiencies, core and copper losses, impedance, regulation and sound level.
- 10.3 Installation of transformers shall be on vibration isolators and all wiring connections with flexible conduit.
- 10.4 Label per Section 16000.22
- 10.5 Approved manufacturers are: ACME, Square D, Jefferson, Cutler-Hammer, Westinghouse, General Electric, or same manufacturer as distribution equipment.
11. CONDUIT
- 11.1 Metallic conduits shall be hot dipped galvanized equal to LTV Steel.
- 11.2 Electric metallic tubing (EMT) is permitted for exposed work above 6'-0" A.F.F. or concealed work only. EMT is NOT permitted in the following: (1) in or under concrete, (2) in earth, (3) in grouted walls, (4) exterior of building, (5) with dissimilar metals, (6) where it will be subject to severe physical damage (either during or after installation), (7) in any hazardous (classified location) except as permitted by 502.10, 503.10 and 504.20, (8) without an equipment grounding conductor. Size and provide equipment grounding conductor per Article 250 and increase conduit size if required.
- 11.3 Rigid PVC conduit is permitted only underground or as noted on drawings. Provide rigid steel elbows and risers (NO MINIMUM SIZE). Size and provide equipment grounding conductor per Article 250 and increase conduit size if required.
- 11.4 Rigid galvanized or sheradized steel shall be used for all exposed conduit below 6'-0" A.F.F. or as noted on drawings. Where used in or under concrete or in earth, shall be code approved PVC coated or half lap wrapped with Polyken #900 tape or equal.
- 11.5 Install exposed raceways parallel and perpendicular to nearby surfaces or structural members and follow the surface contours as much as practical.
- 11.6 Run exposed, parallel, or banked raceways together. Make bends in parallel or banked runs from the same center line so that the bends are parallel. Factory elbows may be used in banked runs only where they can be installed parallel. This requires that there be a change in the plane of the run such as from wall to ceiling and that the raceways be of the same size. In other cases provide field bends for parallel raceways.
12. WIRE
- 12.1 Soft drawn annealed copper (unless otherwise noted on plans) having conductivity of not less than 98% of that of pure copper, uniform in cross section, free from flaws, scales, and other imperfections. All wire larger than #10 shall be stranded.
- 12.2 Insulation: Type THHN/THWN, or XHHW for all branch circuit and feeder wiring.
- 12.3 Sizes: No wire smaller than #12 unless otherwise noted on drawings.
- 12.4 Feeder conductors #2 awg and larger may be copper or AA-8000 series aluminum alloy. Aluminum conductors shall be equal or larger ampacity to copper. Conduit fill shall not exceed 40% factor as described in 2005 NEC, annex C, table C1 (copper) or C1A (aluminum).
13. MISCELLANEOUS MATERIALS:
- 13.1 Safety switches: Heavy duty, fused rejection type, minimum 200,000 A.I.C. rated. "NF" indicates not fused.
- 13.1.1 Label per Section 16000.22
- 13.1.2 Approved manufacturers are: Square D, Cutler-Hammer, Westinghouse, General Electric or same manufacturers as distribution equipment.
- 13.2 Fuses: "Busmann" or "Coulb Shawmut" mfg. No substitutions unless by prior written approval from Engineer, or as noted on drawings.
- 13.3 Conduit strap: Heavy gauge steel snap-on type.
- 13.4 Electrical metallic tubing fittings: Equal to T&B type. Connectors shall have insulated bushings.
- 13.5 Rigid conduit locknuts and bushings: Equal to T&B.
- 13.6 Flexible conduit and fittings: Equal to California Conduit and Cable Company, Inc.
- 13.7 Liquid tight conduit and fittings for all exterior and equipment connections.
- 13.8 Outlet boxes, plaster rings, pull, and junction boxes, etc: Equal to RACO. Zinc coated or Cadmium plated sheet steel for indoor locations, cast aluminum for outdoor locations.
- 13.8.1 For all light fixtures: Octagon or 4" square boxes.
- 13.8.2 For switches and receptacles: 4" or 4-11/16" square boxes.
- 13.8.3 Junction and pull boxes: 4" square minimum size. Provide with screwfastened covers located in accessible locations.
- 13.9 Condulets: Equal to Crouse-Hinds.
- 13.10 Wire and Cable: Equal to General Cable and/or Simplex.
- 13.11 Devices: "Hubbell", "Leviton", or approved equal. Receptacles: Duplex-20 amp #5362, isolated ground - 20 amp #IG-5362, GFCI- 20 amp #GF-5362. Switches: 20 amp #1221 single pole, 1222 double pole, 1223 three way, 1224 four way. Colors to be specified by Architect/Owner/Tenant.
- 13.12 Device plates: "Hubbell", "Leviton", or equal. Ivory nylon in interior areas or as noted on drawings. Zinc die cast flip lid mounted horizontally for exterior or weatherproof locations.

- 13.13 Lighting fixtures: Equal to as shown on fixture schedule or described on drawings, complete with lamps in original cartons and all canopies, stems, hangers and accessories including all structural members required for proper mounting. All fluorescent fixture ballasts shall be energy saving type. Submit shop drawings to Architect/Engineer for approval by the same. Must be C.E.C. approved in Calif.
- 13.14 Lamps: G.E. or equal and shall be for the maximum rated wattage of fixture unless otherwise shown on drawings.
14. SLEEVES, INSERTS, OPENINGS
- 14.1 Contractor shall layout and install his work in advance of pouring concrete floors or walls. Provide all sleeves and/or openings through floors or walls required for electrical conduits or ducts.
- 14.2 Sleeves shall be of rigid conduit or galvanized sheet steel rigidly supported and suitably packed to prevent entrance of wet concrete.
15. EXCAVATION/CUTTING/FITTING/REPAIRING/FINISHING
- 15.1 The Contractor shall include in his bid all excavation, compaction, fill, backfill, cutting, fitting, repairing and finishing of all work necessary for the installation of all equipment under this specification but no cutting of the work of other Contractors shall be done without the consent of the General Contractor.
- 15.2 Earthwork shall be done in accordance with latest industry standards.
16. CLEANUP OF PREMISES
- Contractor shall at all times keep the premises clear of waste materials and debris caused by his employees and operation. Equipment not required in the work shall be removed prior to the termination of the contract.
17. TESTS AND INSPECTIONS
- 17.1 Contractor shall test wiring and devices as sections are completed and shall correct all defects immediately at his own expense, including any damage to walls, ceilings, floor or other portions of the building which may result from replacing defective equipment.
- 17.2 Furnish all meters, cable, connections and apparatus necessary for making tests.
- 17.3 Test system for shorts and grounds. Faulty wiring shall be removed and replaced. Any device, apparatus or fixture installed showing substandard performance shall be removed and replaced as directed by the Architect/Engineer.
- 17.4 Megger all systems neutrals to insure the neutral is not grounded within the system.
- 17.5 All equipment rated at 1,000 amps or more , or 480 volts shall be tested for insulation breakdown prior to its being energized. Such equipment shall withstand for a period of one minute without breakdown, the application of a 60HZ alternating potential of 1,000V plus twice the rated voltage of the device.
- 17.6 After the electrical wiring system installation is completed and at such time as the Architect/Engineer or his authorized representative may direct, the Contractor shall conduct an operating test for approval. Equipment shall be demonstrated to operate in accordance with requirements of specifications. Test shall be performed in presence of Architect/Engineer or his representative.
18. SHOP DRAWINGS
- 18.1 All data shall be submitted at one time, bound and indexed in an orderly manner. Prior to starting the work, submit to the Architect/Engineer for approval, six (6) sets of shop drawings of service (S.E.S.), panels, distribution sections, light fixtures, motor control centers, fire alarm system, dimmers, sound system, emergency generator, devices, transformers, labels as required by 16000.22, and all other equipment to be fabricated.
- 18.2 Procure shop drawings, wiring diagrams, etc., from other trades involved where such drawings may facilitate and expedite the work. Air conditioning and mechanical equipment shall be wired complete as per manufacturer's wiring diagrams furnished by the air conditioning and mechanical contractors.
19. DRAWINGS OF RECORD (AS-BUILT)
- As-built drawings shall be submitted in accordance with and if required by Division 1 – General Requirements.
20. GUARANTEE
- The Contractor shall guarantee all material and equipment to be free from defect of material and workmanship and shall replace or repair without cost to the owner all defective material and workmanship for a period of one year after final acceptance.
21. INSTRUCTIONS
- 21.1 Contractor shall instruct the Owner in the proper operating and maintenance of the equipment.
- 21.2 Contractor shall provide two (2) sets of operating and maintenance manuals for each piece of equipment provided by this discipline, only when such manuals are available from the manufacturer.

(SOME SECTIONS MAY NOT APPLY)

F

NAJAFI RANCH

525 BOYNTON CANYON ROAD

Professional Engineer Certificate No. 31772 DAVID G. WATSON State of Arizona Expires 5/31/16

Douglas Fredrikson Architects
727 east bethany home road, d-123
phoenix, arizona 85014
602.277.1625

these documents are instruments of service of the authors and are for use on this project only. they are prepared for use in conjunction with the authors interpretations, observations, decisions, and administration as described in aia doc a201, without which desired result can not be assured. alteration, reproduction, or use in part or in whole, for other purposes without the authors written consent may violate existing legal statutes.

13100

electrical specifications

issue date

10.25.2015

revisions

City Comments 12.17.15

e

201

Job No. 15231

David Watson, P.E.

dawew@mwegroup.com

o 480.731.5050 f 480.731.5353

2001 W Alameda Drive, Suite 102 Tempe, AZ 85282

mw engineering, llc

Electrical Consulting Engineering Group

(SOME SECTIONS MAY NOT APPLY)

21.2.1 All manuals to be bound in a 3-ring binder and tabulated in an orderly manner.

22. LABELING

22.1 Labels shall be engraved, black on white melamine laminated, 1/16" minimum thickness for signs up to 20 square inches or 8 inches long; 1/8" thick for larger sizes. Engraved legend shall be in white letters on black face with minimum 3/16" high letters. Labels shall be punched and fastened to equipment with aluminum rivets or self tapping stainless steel screws or number 10/32 stainless steel machine screws with nuts, flat and lock washers.

22.2 Label equipment with name, amperage, voltage, phase, and wires (i.e. Panel "A", 400A, 120/208V,30,4W).

Submit list of all labels with wording for review as per 16000.18.

22.3 Equipment to be labeled shall include service disconnect devices, distribution sections and all all overcurrent devices, motor control centers (M.C.C.) and all overcurrent devices, fusible panelboards and all overcurrent devices, panels, starters and transformers. Label other equipment as noted on plans.



these documents are instruments of service of the authors and are for use on this project only. They are prepared for use in conjunction with the authors' interpretations, observations, decisions, and administration as described in aia doc a201 without which desired result can not be assured. Alteration, reproduction, or use in part or in whole for other purposes without the authors' written consent may violate existing legal statutes.

electrical specifications

issue date

10. 25 . 2015

revisions

4-UP-2013
11/12/15


 **Job No. 15231**
David Watson, P.E.
davew@mwegroup.com
o 480.731.5050 f 480.731.5353
2001 W Alameda Drive, Suite 102 Tempe, AZ 85282

mw engineering, llc
Electrical Consulting Engineering Group

LIGHT FIXTURE SCHEDULE



MARK	DESCRIPTION	MFR.	CATALOG #	VOLT.	LAMPS		REMARKS
					#	TYPE	
A	PENDANT MTD LED	BARN LIGHT	SWH17650 ST36	120	1	GU24 BI-PIN 18W	12'-0" FIXTURE HEIGHT ABOVE FINISHED GRADE
B	PENDANT MTD LED	BARN LIGHT	SWH13650 ST24	120	1	GU24 BI-PIN 18W	12'-0" FIXTURE HEIGHT ABOVE FINISHED GRADE
C	LED WALL SCONCE	BARN LIGHT	WWHA8-PC 600	120	-	-	MOUNT AT 6'-6"
D	LED AREA LIGHT	BARN LIGHT	WWHA10-PC 600	120	-	-	MOUNT AT EDGE
F	LED WALL SCONCE	BARN LIGHT	WWHA10-PC 600	120	-	-	-
G	LENSED LED SECURITY LIGHT	COLUMBIA	LXEW430HCP WEUDWH	120	-	LED	-
H	LED WALL SCONCE	BARN LIGHT	WWHA8-PC-100	120	-	-	-
K	LED LANDSCAPE LIGHT	BK	DS LED E22 MFL A9 BLW 12 A 360SL	120	-	-	AIM AWAY FROM PROPERTY LINE

* NOTE:
FLUORESCENT FIXTURES SHALL CONTAIN A BALLAST DISCONNECTING MEANS IN ACCORDANCE WITH N.E.C. ARTICLE 410.130(G).

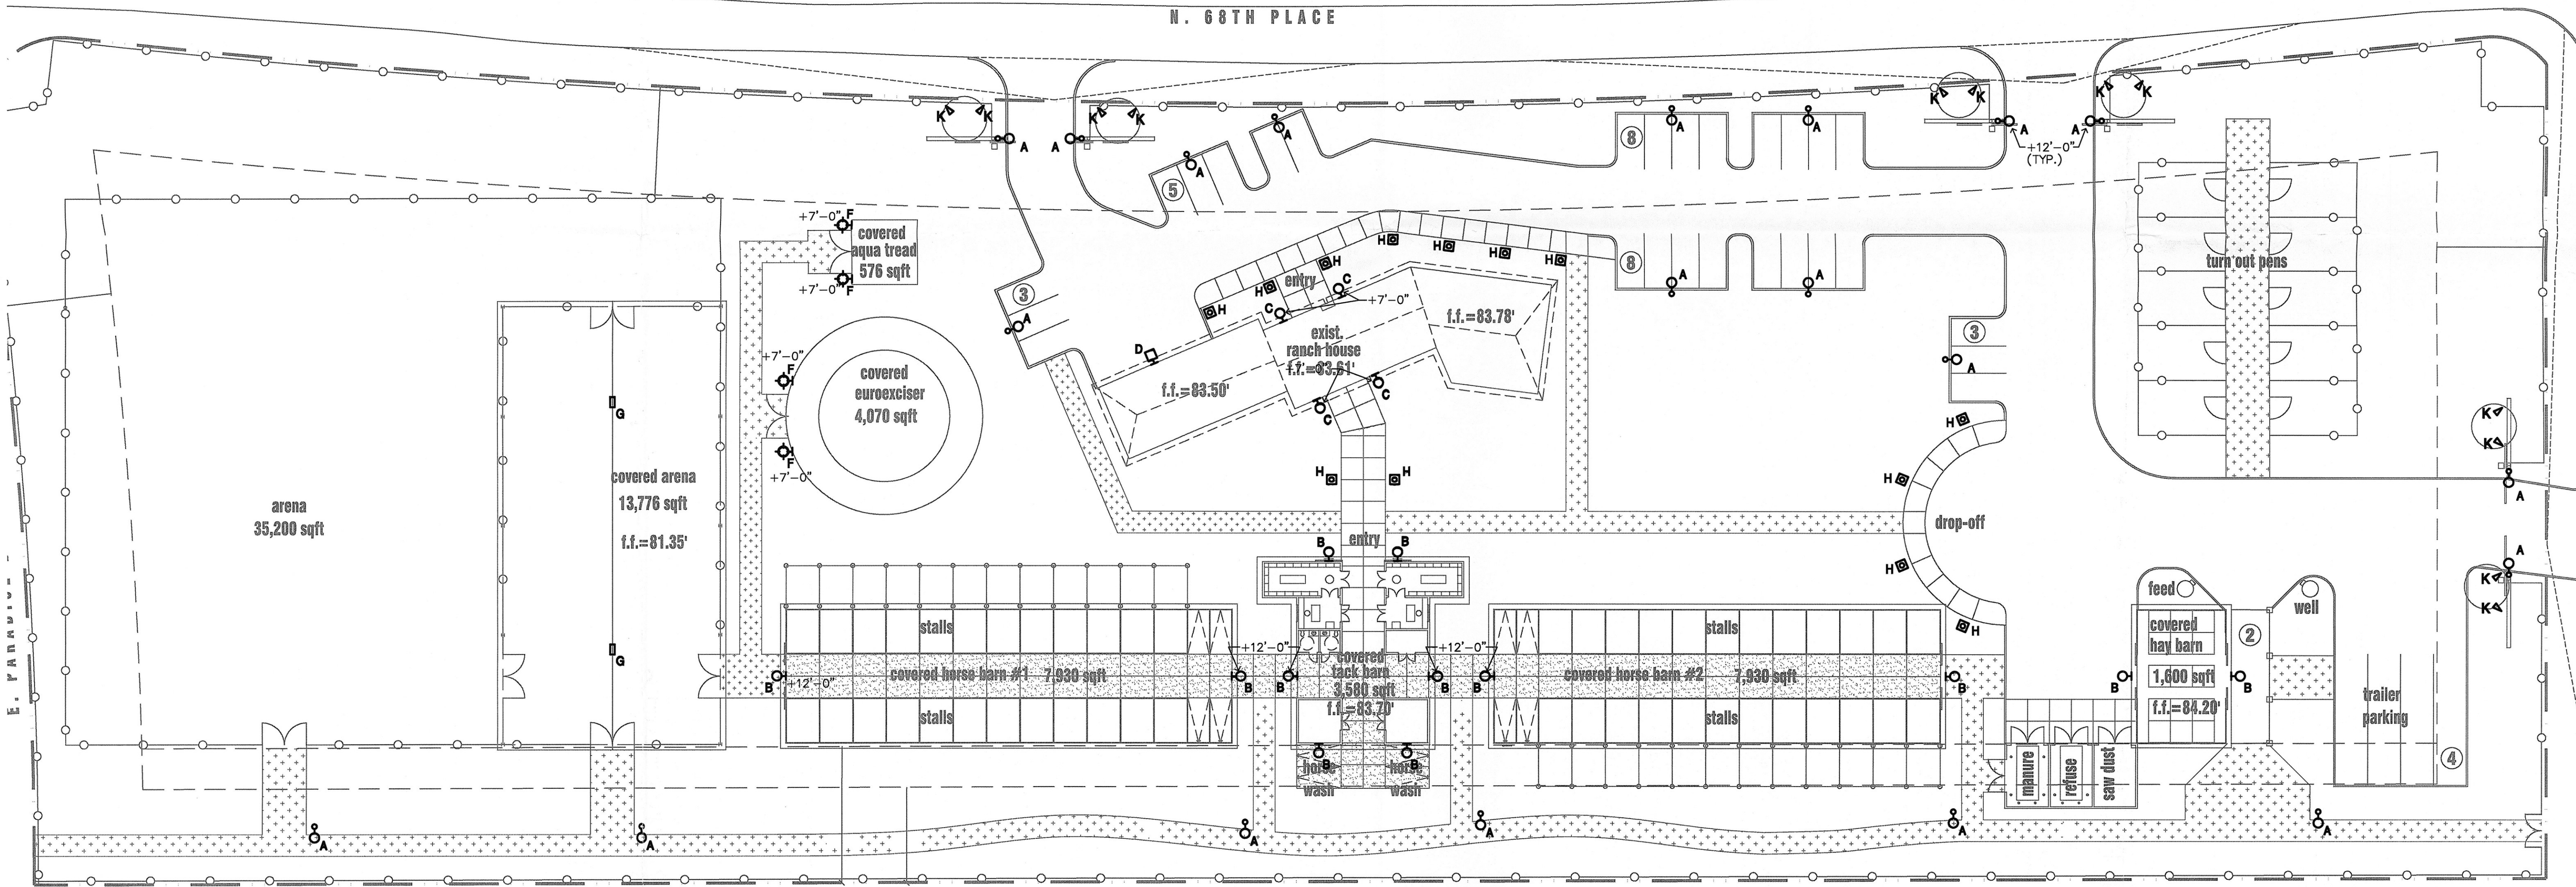

site lighting plan

 scale: 1" = 30'-0"

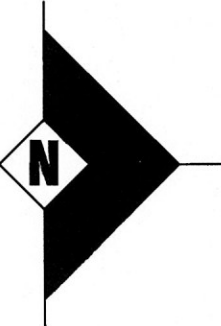

mw engineering, llc
Electrical Consulting Engineering Group

Job No. 15231
David Watson, P.E.
davew@mwgroup.com
o 480.731.5950 f 480.731.5363
2001 W Alameda Drive, Suite 102, Tempe, AZ 85282

NAJAFI RANCH

525 BOYNTON CANYON ROAD



Douglas Fredrikson Architects
727 east bethany home road, d-123
phoenix, arizona 85014
602.277.1625

these documents are instruments of service of the authors and are for use on this project only. they are prepared for use in conjunction with the authors interpretations, observations, decisions, and administration as described in this document. without which desired result can not be assured. alteration, reproduction, or use in part or in whole, for other purposes without the authors written consent may violate existing legal statutes.

13100

electrical site lighting plan

issue date

10.25.2015


revisions

e
101



NAJAFI RANCH

525 BOYNTON CANYON ROAD

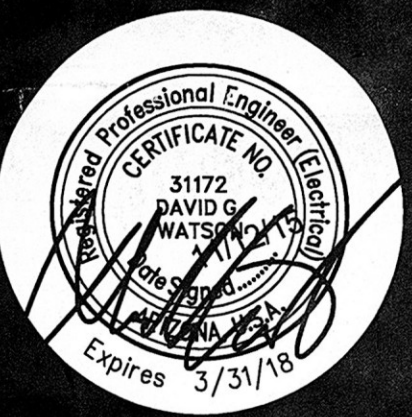

Douglas Fredrikson Architects
727 east bethany home road, d-123
phoenix, arizona 85014
602.277.1625

these documents are instruments of service of the authors and are for use on this project only. they are prepared for use in conjunction with the authors' interpretations, observations, decisions, and administration as described in aia doc a201, without which desired result can not be assured. alteration, reproduction, or use in part or in whole, for other purposes without the authors written consent may violate existing legal statutes.

13100

photometrics - post curfew

issue date

10.25.2015


revisions

e
102

4-UP-2013
11/12/15


Luminaire Schedule							
Label	(TEST)	Symbol	Description	MTG HEIGHT	MOUNTING	Lum. Watts	Qty
A	11773-G	●	BARN LT - S-WH817-650-ST24-650-LED-LMH2-1250	12' MTG HT.	SINGLE	21	20
B	11773-G	●	BARN LT - S-WH817-650-ST24-650-LED-LMH2-1250	12' MTG HT.	SINGLE	21	12
C	11773-G	●	BARN LT - W-WH818-PC-600-LED-LMH2-850LU	6.6' MTG HT.	SINGLE	10	4
D	11773-G	●	BARN LT - W-WH818-PC-600-LED-LMH2-1250	12' MTG HT.	SINGLE	21	1
F	11773-G	●	BARN LTG - W-WH818-PC-600-LED-LMH2-1250	12' MTG HT.	SINGLE	21	4
H	11773-G	●	BARN LT - X-WH818-PC-600-LED-LMH2-850LU	2.5' MTG HT.	SINGLE	10	13
K	1163766	●	DS-LED-223-MFL-13; AR-LED-TK-623-MFL-13-G AR	6 INCH MTG HT.	SINGLE	8.5	12

Calculation Summary							
Label	CalcType	Units	Avg	Max	Min	Avg/Min	Max/Min
PERIMETER 6' ABOVE GRADE	Illuminance	Fc	0.00	0.1	0.0	N.A.	N.A.
SITE - POSTCURFEW	Illuminance	Fc	0.07	9.6	0.0	N.A.	N.A.

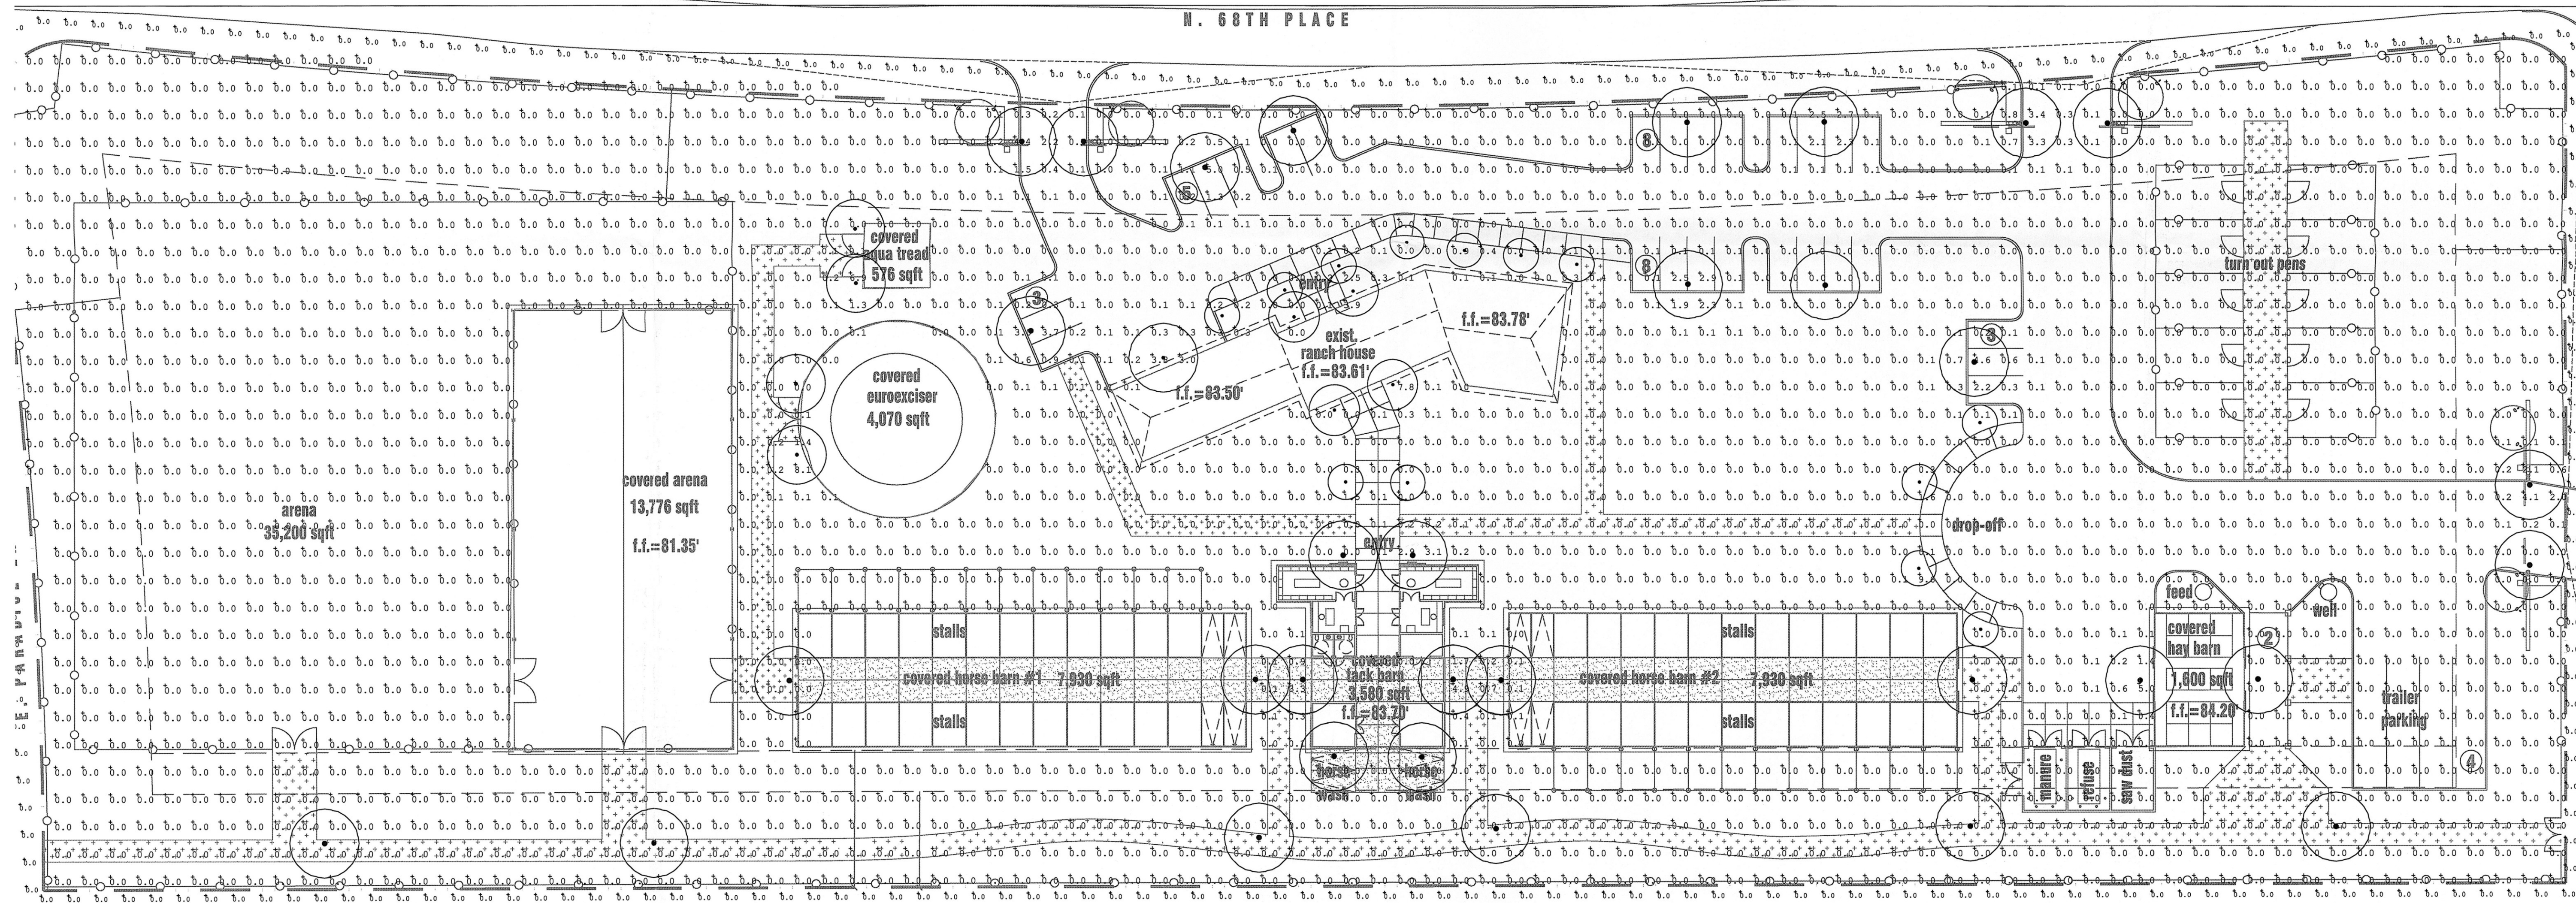

photometrics post curfew

 scale: 1" = 30'-0"





Job No. 15231
David Watson, P.E.
davew@mwegroup.com
o. 480.731.5050 f. 480.731.5353
2001 W Alameda Drive, Suite 102 Tempe, AZ 85282

mw engineering, llc
Electrical Consulting Engineering Group



Douglas Fredrikson Architects
727 east bethany home road, d-123
phoenix, arizona 85014
602.277.1625

these documents are instruments of service of the authors and are for use on this project only. they are prepared for use in conjunction with the authors interpretations, observations, decisions, and administration as described in aia doc a201, without which desired result can not be assured. alteration, reproduction, or use in part or in whole, for other purposes without the authors written consent may violate existing legal statutes.

13100

photometrics - pre curfew


issue date

10.25.2015

revisions


Luminaire Schedule						
Label	(TEST)	Symbol	Description	MTG HEIGHT	MOUNTING	Lum. Watts Qty
A	11773-G	●	BARN LT - S-WHB17-650-ST36-650-LED-LMH2-1250	12' MTG HT.	SINGLE	21 20
B	11773-G	●	BARN LT - S-WHB17-650-ST36-650-LED-LMH2-1250	12' MTG HT.	SINGLE	21 12
C	11773-G	●	BARN LT - W-WHAB-PC-600-LED-LMH2-850LU	6.6' MTG HT.	SINGLE	10 4
D	11773-G	●	BARN LT - W-WHAB-PC-600-LED-LMH2-1250	12' MTG HT.	SINGLE	21 1
F	11773-G	●	BARN LTG - W-WHAB-PC-600-LED-LMH2-1250	12' MTG HT.	SINGLE	21 4
H	11773-G	●	BARN LT - X-WHAB-PC-600-LED-LMH2-850LU	2.5' MTG HT.	SINGLE	10 13
K	1163766	●	DS-LED-425-MR-13, AIR-LED-TN-423-MR-13-C, AR	6 INCH MTG HT.	SINGLE	8.5 12

Calculation Summary						
Label	CalcType	Units	Avg	Max	Min	Avg/Min Max/Min
PERIMETER 6' ABOVE GRADE	Illuminance	FC	0.00	0.1	0.0	N.A. N.A.
SITE - PRECURFEW	Illuminance	FC	0.18	14.9	0.0	N.A. N.A.

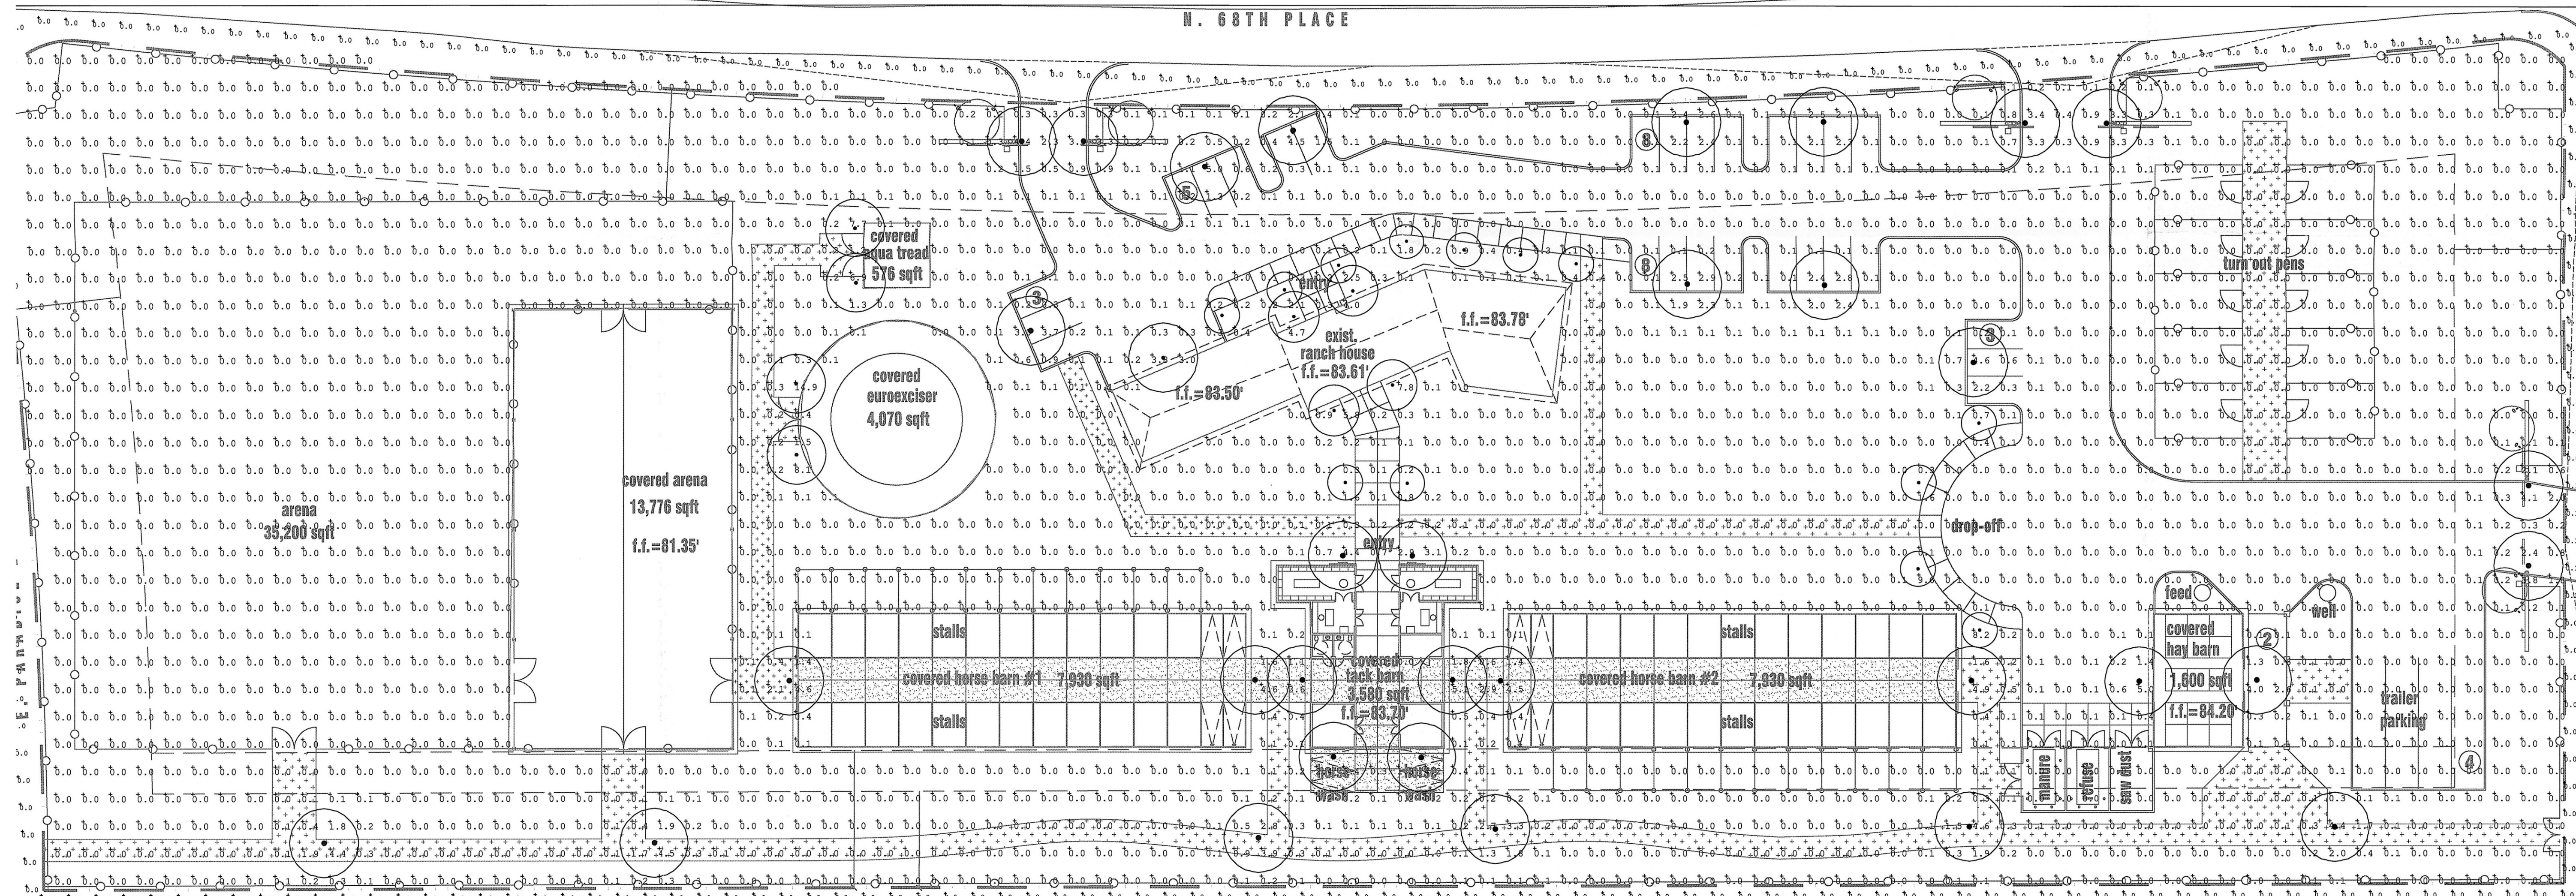

photometrics pre curfew


scale: 1" = 30'-0"

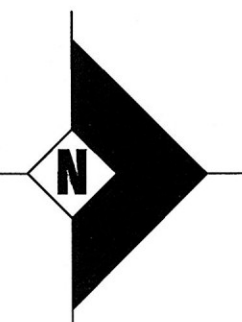

mw engineering, llc
Electrical Consulting Engineering Group

Job No. 15231
David Watson, P.E.
dave@mwgroup.com
480.731.5050 f. 480.731.5353
2001 W Alameda Drive, Suite 102 Tempe, AZ 85282

Columbia LIGHTING

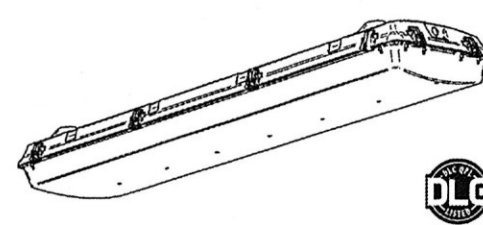

FEATURES

- High efficiency LED in choice of lumen packages and colors
- Long-life, 60,000 hour LEDs at L80 (projected over 100,000 hours) for reduced life cycle maintenance costs
- Available in narrow or wide distribution
- IP65, IP66, and IP67 rated
- 1500 PSI High Pressure Hose down rating
- Fiberglass housing with F1 weatherability rating, standard
- Gasket is non-porous to ensure seal
- Impact modified acrylic lenses
- Lens selections include clear, frosted, or clear polycarbonate
- Lens firmly secured with tamper resistance ready latches
- Lens is tethered and gear tray hinges for ease of maintenance
- Stainless steel latching and mounting straps optional
- Removable gear tray electrical access
- Hy-Vok mounting brackets included standard
- Elevated ambient rating with HT optional
- Thermal table below provides details elevated ambient offerings
- Available with exclusive w/Hubb technology preinstalled
- DesignLights Consortium™ (DLC) qualified
- Five Year Warranty

PROJECT INFORMATION
NAJAFI RANCH
Project Name
LXEW-40VLCPEUWH
Catalog No.

TYPE G

LXEW
Enclosed and Gasketed High Bay / LED

CONSTRUCTION
Fiberglass reinforced housing and tough injection molded lens. Hinged driver tray for easy maintenance. Industrial fixture design allows for easy cleaning and dust and water accumulation. 12 captive polycarbonate (POM) latches and four fixed installation points secure the fixture during transit and allows for fast installation.

REFLECTOR
Special reflector provides precise control and excellent efficiency for narrow distribution. Wide distribution uses high gloss white gear tray; select the HT option for added efficiency.

ELECTRICAL
Long-life LEDs are rated for 60,000 hours at L80 lumen maintenance. Driver options include fixed output for on/off function, step dimming (high/low/off) or continuous 0-10V dimming. OR case label affixed to housing for easy traceability.

FINISH
Housing has chemical resistant finish. Internal steel surfaces are painted with high gloss baked white enamel, applied over iron phosphate pre-treatment for maximum adhesion and rust resistance. Stainless steel parts have fine brushed mill finish.

MOUNTING
Fixture is intended to be surface or suspended mounted. Surface mounting requires use of the proper accessories listed below. To suspend the fixture use aircraft cable or chain (See Accessories). V-Hook mounting brackets included standard.

CERTIFICATION
All luminaires are built to UL 1598 and 2108 wet location standards and have IP65/IP66/IP67 hose down ratings, and bear appropriate CSA labels. Housing and lens are made with 5VA (1) fire rated materials. All LXEW fixtures are NSF rated for Splash Zones. See table on page 2 for elevated ambient ratings. DesignLights Consortium™ (DLC) qualified. Please refer to the DLC website for specific product qualifications at www.designlights.org.

EXAMPLE LXEW-40VL-W-EDU

ORDERING INFORMATION				EXAMPLE LXEW-40VL-W-EDU			
LXEW	SIZE	COLOR TEMP	LENS	DISTRIBUTION	VOLTAGE	OPTIONS	
LXEW	4' 4"	30 3000K 35 3500K 40 4000K 50 5000K	FA Front Impact Resistant Acrylic (Std) CA Clear Impact Resistant Acrylic CP Clear HT Stabilized Polycarbonate	N Narrow W Wide Distribution	U 120V-277V	GLR Fast Blow Fuse SSL Stainless Steel TP Tamper Proof Latches ELL14 Emergency Battery Pack Installed, 3400 Lumens F3CBW 3 Wire 8" Wet Cord F3C15W 3 Wire 15" Wet Cord SWH Single Wet Hub 1/4" NPT Hub DWH Dual Wet Hub 1/4" NPT Hub WTH w/Hubb Enabled HT Elevated Ambient PAF Paint After Fabrication	
ACCESSORIES (ORDER SEPARATELY)				LUMEN OUTPUT			
L10WMS Aircraft Cable, 5' (Std)				L Low Lumen			
L10WMS Aircraft Cable, 10' (Std)				M Medium Lumen			
XEWMSMS Mounting Strap Hardware Kit, Stainless Steel, includes 4				H High Lumen			
XEWMSBZ Rigid Surface Mounting Bracket Kit, 2pc (Std), includes 2				V Very High Lumen ¹			
XEWMSBS Rigid Surface Mounting Bracket Kit, Stainless Steel, includes 2							
XEWMSBS Surface Mounting Bracket Kit, Stainless Steel, includes 2							

¹Not available with HT option.

²HT option temperature ratings may vary with lumen packages.
Please consult specific catalog pages for full details and ratings.
NAJAFI 3000K.

Page 1/3 Rev. 09/23/15


© 2015 Columbia Lighting, a division of Hubbell Lighting, Inc. Specifications subject to change without notice.
701 Millennium Blvd. Greenville, SC 29607 / Tel 864.678.1000 / Website www.columbialighting.com

EXTREME ENVIRONMENT / LXEW

HUBBELL
Lighting

TYPES A & B

SP0054 REV A

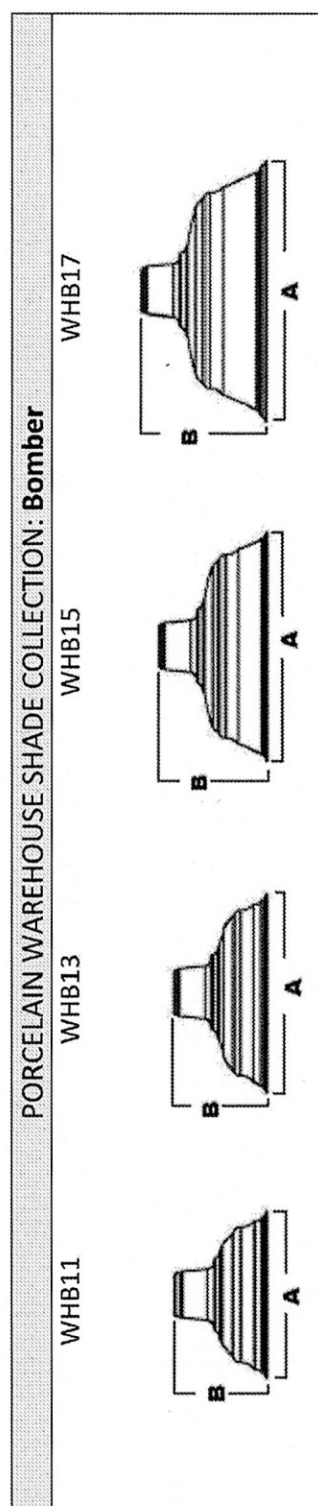


Item #	Standard	Height (ft)	Height (in)
WHB11	150-Black	15"	6"
WHB13	250-White	15"	6"
WHB15	350-Indie	15"	6"
WHB17	450-Indie	15"	6"

Model #	Item #	Standard	Height (ft)	Height (in)	Mounting Options	Mounting Color	Optional Accessories	Accessory Colors	Wattage/Lamp Options	Ballast	Voltage
W-B-C	WHB11	150-Black	15"	6"	Standard ¹ : Black White Red Chevron Gray Black Brown Black Putty Stem: 31 Gooseneck: G Chain Hang: N Chain Hang: N Standard length is 3 ft. For additional mounting options and details, see additional mounting options chart.	Standard finish for ALL mounting is: Same as fixture / Leave Code Blank OR Coat: 150-Black 250-White 350-Indie 450-Indie Stem and Gooseneck: 110-Black 110-White 975-Galvanized 980-Brushed Aluminum Chain: Chain: 110-Black 110-White 975-Galvanized For additional colors, see color chart.	Standard finish for ALL mounting is: Same as fixture / Leave Code Blank OR Coat: 150-Black 250-White 350-Indie 450-Indie Stem and Gooseneck: 110-Black 110-White 975-Galvanized 980-Brushed Aluminum Chain: Chain: 110-Black 110-White 975-Galvanized For additional colors, see color chart.	Standard finish for ALL mounting is: Same as fixture / Leave Code Blank OR Coat: 150-Black 250-White 350-Indie 450-Indie Stem and Gooseneck: 110-Black 110-White 975-Galvanized 980-Brushed Aluminum Chain: Chain: 110-Black 110-White 975-Galvanized For additional colors, see color chart.	Standard finish for ALL mounting is: Same as fixture / Leave Code Blank OR Coat: 150-Black 250-White 350-Indie 450-Indie Stem and Gooseneck: 110-Black 110-White 975-Galvanized 980-Brushed Aluminum Chain: Chain: 110-Black 110-White 975-Galvanized For additional colors, see color chart.	Standard finish for ALL mounting is: Same as fixture / Leave Code Blank OR Coat: 150-Black 250-White 350-Indie 450-Indie Stem and Gooseneck: 110-Black 110-White 975-Galvanized 980-Brushed Aluminum Chain: Chain: 110-Black 110-White 975-Galvanized For additional colors, see color chart.	Standard finish for ALL mounting is: Same as fixture / Leave Code Blank OR Coat: 150-Black 250-White 350-Indie 450-Indie Stem and Gooseneck: 110-Black 110-White 975-Galvanized 980-Brushed Aluminum Chain: Chain: 110-Black 110-White 975-Galvanized For additional colors, see color chart.

Notes:
¹Suitable for Dry locations Only (Not CSA listed). Standard length is 3 ft. *Additional lengths available on Cord, Stem & Chain.
²Gooseneck, Chain, Stem & Accessories are painted to match porcelain finish. *Guard/Glass options reduce wattage to 100W. Suitable for Wet Location (except when cord mounted).

TYPE K

DELTA STAR™

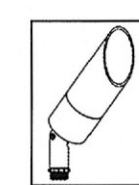

CATALOG NUMBER LOGIC

Example: DS - LED - e22 - SP - A7 - BZW - 12 - 11 - A - 360SL

Material:
Blank - Aluminum
B - Brass
S - Stainless Steel

Series:
DS - Delta Star™

Source:
LED - 'u' Technology with Integral Dimming Driver (25W min. load when dimmed)
Requires magnetic Low Voltage Dimmer

LED Type:
e36 - BWLED/2.7K
e22 - BWLED/3K
e23 - BWLED/4K
e27 - BWLED/Amber

Optics:
NSP - Narrow Spot (Red Indicator)
SP - Spot (Green Indicator)
MFL - Medium Flood (Yellow Indicator)
WFL - Wide Flood (Blue Indicator)

Adjust-e-Lume™ Output Intensity™ (Choose factory setting)
A9 (Standard), A8, A7, A6, A5, A4, A3, A2, A1
**Please use Adjust-e-Lume™ photography to determine desired intensity.

Aluminum Finish				Brass Finish				Premium Finish			
Powder Coat Color	Satin	Wrinkle	Machined	MAC	ABP	Antique Brass Powder	CMG	Cascade Mountain Granite	RMG	Rocky Mountain Granite	
Bronze	BZP	BZW	Polished	POL	AMG	Aluminum Mountain Granite	CRJ	Crooked Ice	SDS	Sonoran Desert Sandstone	
Black	BLP	BLW	Milquique™	MIT	AQW	Antique White	CRM	Cream	SMG	Serra Mountain Granite	
White (Gloss)	WHP	WHW	Stainless Finish		BCM	Black Chrome	HUG	Hunter Green	TXF	Textured Forest	
Aluminum	SAP	---	Machined	MAC	BGE	Beige	MDS	Mojave Desert Sandstone	WCP	Weathered Copper	
Verde	---	VER	Polished	POL	BPP	Brown Patina Powder	NBP	Natural Brass Powder	WIR	Weathered Iron	
			Brushed	BRU	CAP	Clear Anodized Powder	OCF	Old Copper			

Lens Type:
12 - Soft Focus Lens
13 - Rectilinear Lens

Shielding:
A - 45°
B - 90°
D - 45° Intra Weep Hole (Interior Use Only)
E - 90° Intra Weep Hole (Interior Use Only)

Cap Style:
A - 45°
B - 90°
D - 45° Intra Weep Hole (Interior Use Only)
E - 90° Intra Weep Hole (Interior Use Only)

Option:
360SL - 360SL™ Rotational Knuckle Mounting System

DRIVER DATA				LM79 DATA				*OPTICAL DATA			
BK No.	CCT (Typ.)	Input Watts	CRB (Typ.)	Minimum Rated Life (hrs.)	20% of rated lumen flux	Beam Type	Angle	Visual Indicator	Beam Type	Angle	Visual Indicator
e36	2700K	8.4	90	50,000		Narrow Spot	14°	Red Dot	Narrow Spot	14°	Red Dot
e22	3100K	8.4	90	50,000		Spot	18°	Green Dot	Spot	18°	Green Dot
e23	4100K	8.4	75	50,000		Medium Flood	25°	Yellow Dot	Medium Flood	25°	Yellow Dot
e27	Amber (590nm)	7.9	---	50,000		Wide Flood	36°	Blue Dot	Wide Flood	36°	Blue Dot

B-K LIGHTING

40429 Brimley Drive • Modesto, CA 95308 • USA
866.438.8800 • FAX 520.438.5900
www.bklighting.com • info@bklighting.com


SUBMITTAL DATE

DRAWING NUMBER
SUB000930

THIS DOCUMENT CONTAINS PROPRIETARY INFORMATION OF B-K LIGHTING, INC. AND ITS RECEIPT OR POSSESSION DOES NOT CONVEY ANY RIGHTS TO REPRODUCE, DISCLOSE ITS CONTENTS, OR TO MANUFACTURE, USE OR SELL ANYTHING IF ANY DISCLOSE, REPRODUCTION, DISCLOSURE OR USE WITHOUT SPECIFIC WRITTEN AUTHORIZATION OF B-K LIGHTING, INC. IS STRICTLY PROHIBITED.

TYPES C, D, F & H

SP0014 REV A

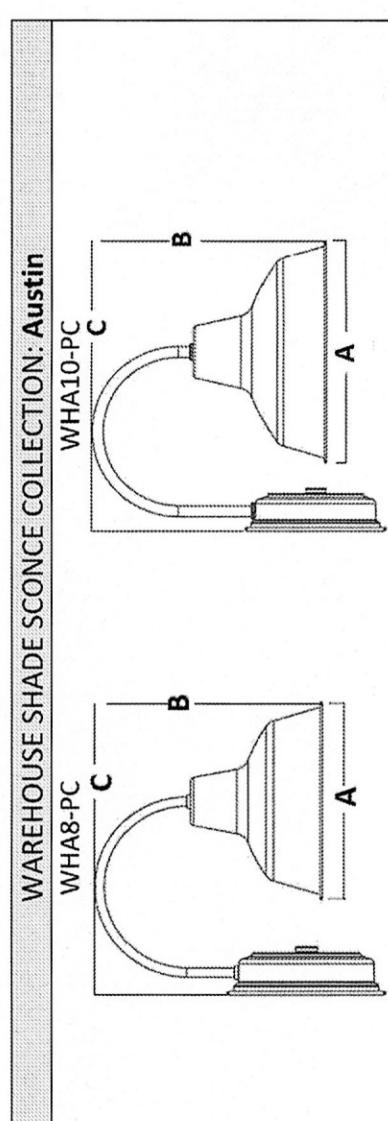

Item #	Standard	Height (ft)	Height (in)
WHB11	150-Black	15"	6"
WHB13	250-White	15"	6"
WHB15	350-Indie	15"	6"
WHB17	450-Indie	15"	6"

Model #	Item #	Standard	Height (ft)	Height (in)	Mounting Options	Mounting Color	Optional Accessories	Accessory Colors	Wattage/Lamp Options	Ballast	Voltage
W-SC	WHB11	150-Black	15"	6"	Standard ¹ : Black White Red Chevron Gray Black Brown Black Putty Stem: 31 Gooseneck: G Chain Hang: N Chain Hang: N Standard length is 3 ft. For additional mounting options and details, see additional mounting options chart.	Standard finish for ALL mounting is: Same as fixture / Leave Code Blank OR Coat: 150-Black 250-White 350-Indie 450-Indie Stem and Gooseneck: 110-Black 110-White 975-Galvanized 980-Brushed Aluminum Chain: Chain: 110-Black 110-White 975-Galvanized For additional colors, see color chart.	Standard finish for ALL mounting is: Same as fixture / Leave Code Blank OR Coat: 150-Black 250-White 350-Indie 450-Indie Stem and Gooseneck: 110-Black 110-White 975-Galvanized 980-Brushed Aluminum Chain: Chain: 110-Black 110-White 975-Galvanized For additional colors, see color chart.	Standard finish for ALL mounting is: Same as fixture / Leave Code Blank OR Coat: 150-Black 250-White 350-Indie 450-Indie Stem and Gooseneck: 110-Black 110-White 975-Galvanized 980-Brushed Aluminum Chain: Chain: 110-Black 110-White 975-Galvanized For additional colors, see color chart.	Standard finish for ALL mounting is: Same as fixture / Leave Code Blank OR Coat: 150-Black 250-White 350-Indie 450-Indie Stem and Gooseneck: 110-Black 110-White 975-Galvanized 980-Brushed Aluminum Chain: Chain: 110-Black 110-White 975-Galvanized For additional colors, see color chart.	Standard finish for ALL mounting is: Same as fixture / Leave Code Blank OR Coat: 150-Black 250-White 350-Indie 450-Indie Stem and Gooseneck: 110-Black 110-White 975-Galvanized 980-Brushed Aluminum Chain: Chain: 110-Black 110-White 975-Galvanized For additional colors, see color chart.	Standard finish for ALL mounting is: Same as fixture / Leave Code Blank OR Coat: 150-Black 250-White 350-Indie 450-Indie Stem and Gooseneck: 110-Black 110-White 975-Galvanized 980-Brushed Aluminum Chain: Chain: 110-Black 110-White 975-Galvanized For additional colors, see color chart.

Notes:
¹Canopy diameter is standard 6 1/4". Suitable for Wet Location



NAJAFI RANCH

525 BOYNTON CANYON ROAD



Douglas Fredrikson Architects
727 east bethany home road, d-123
phoenix, arizona 85014
602.277.1625

these documents are instruments of service of the authors and are for use on this project only, they are prepared for use in conjunction with the authors interpretations, observations, decisions, and administration as described in site doc 42071, without which desired result can not be assured, alteration, reproduction, or use in part or in whole, for other purposes without the authors written consent may violate existing legal statutes.

13100

light fixture cut-sheets

issue date

10.25.2015

revisions



mw engineering, llc
Electrical Consulting Engineering Group
Job No. 15231
David Watson, P.E.
dave@mwengr.com
o. 480.731.5050 f. 480.731.5353
2001 W Alameda Drive, Suite 102 Tempe, AZ 85282