

THE OSBORN

3380 N Scottsdale Road,
Scottsdale AZ, 85251

Gensler


2575 E Camelback Road
Suite 175
Phoenix, AZ 85016
United States
Office Information

Tel 6025234900
Fax 6025234949

SYDNR

4806 N 78th Place
Scottsdale
AZ 85251
United States

Tel 480.206.4593

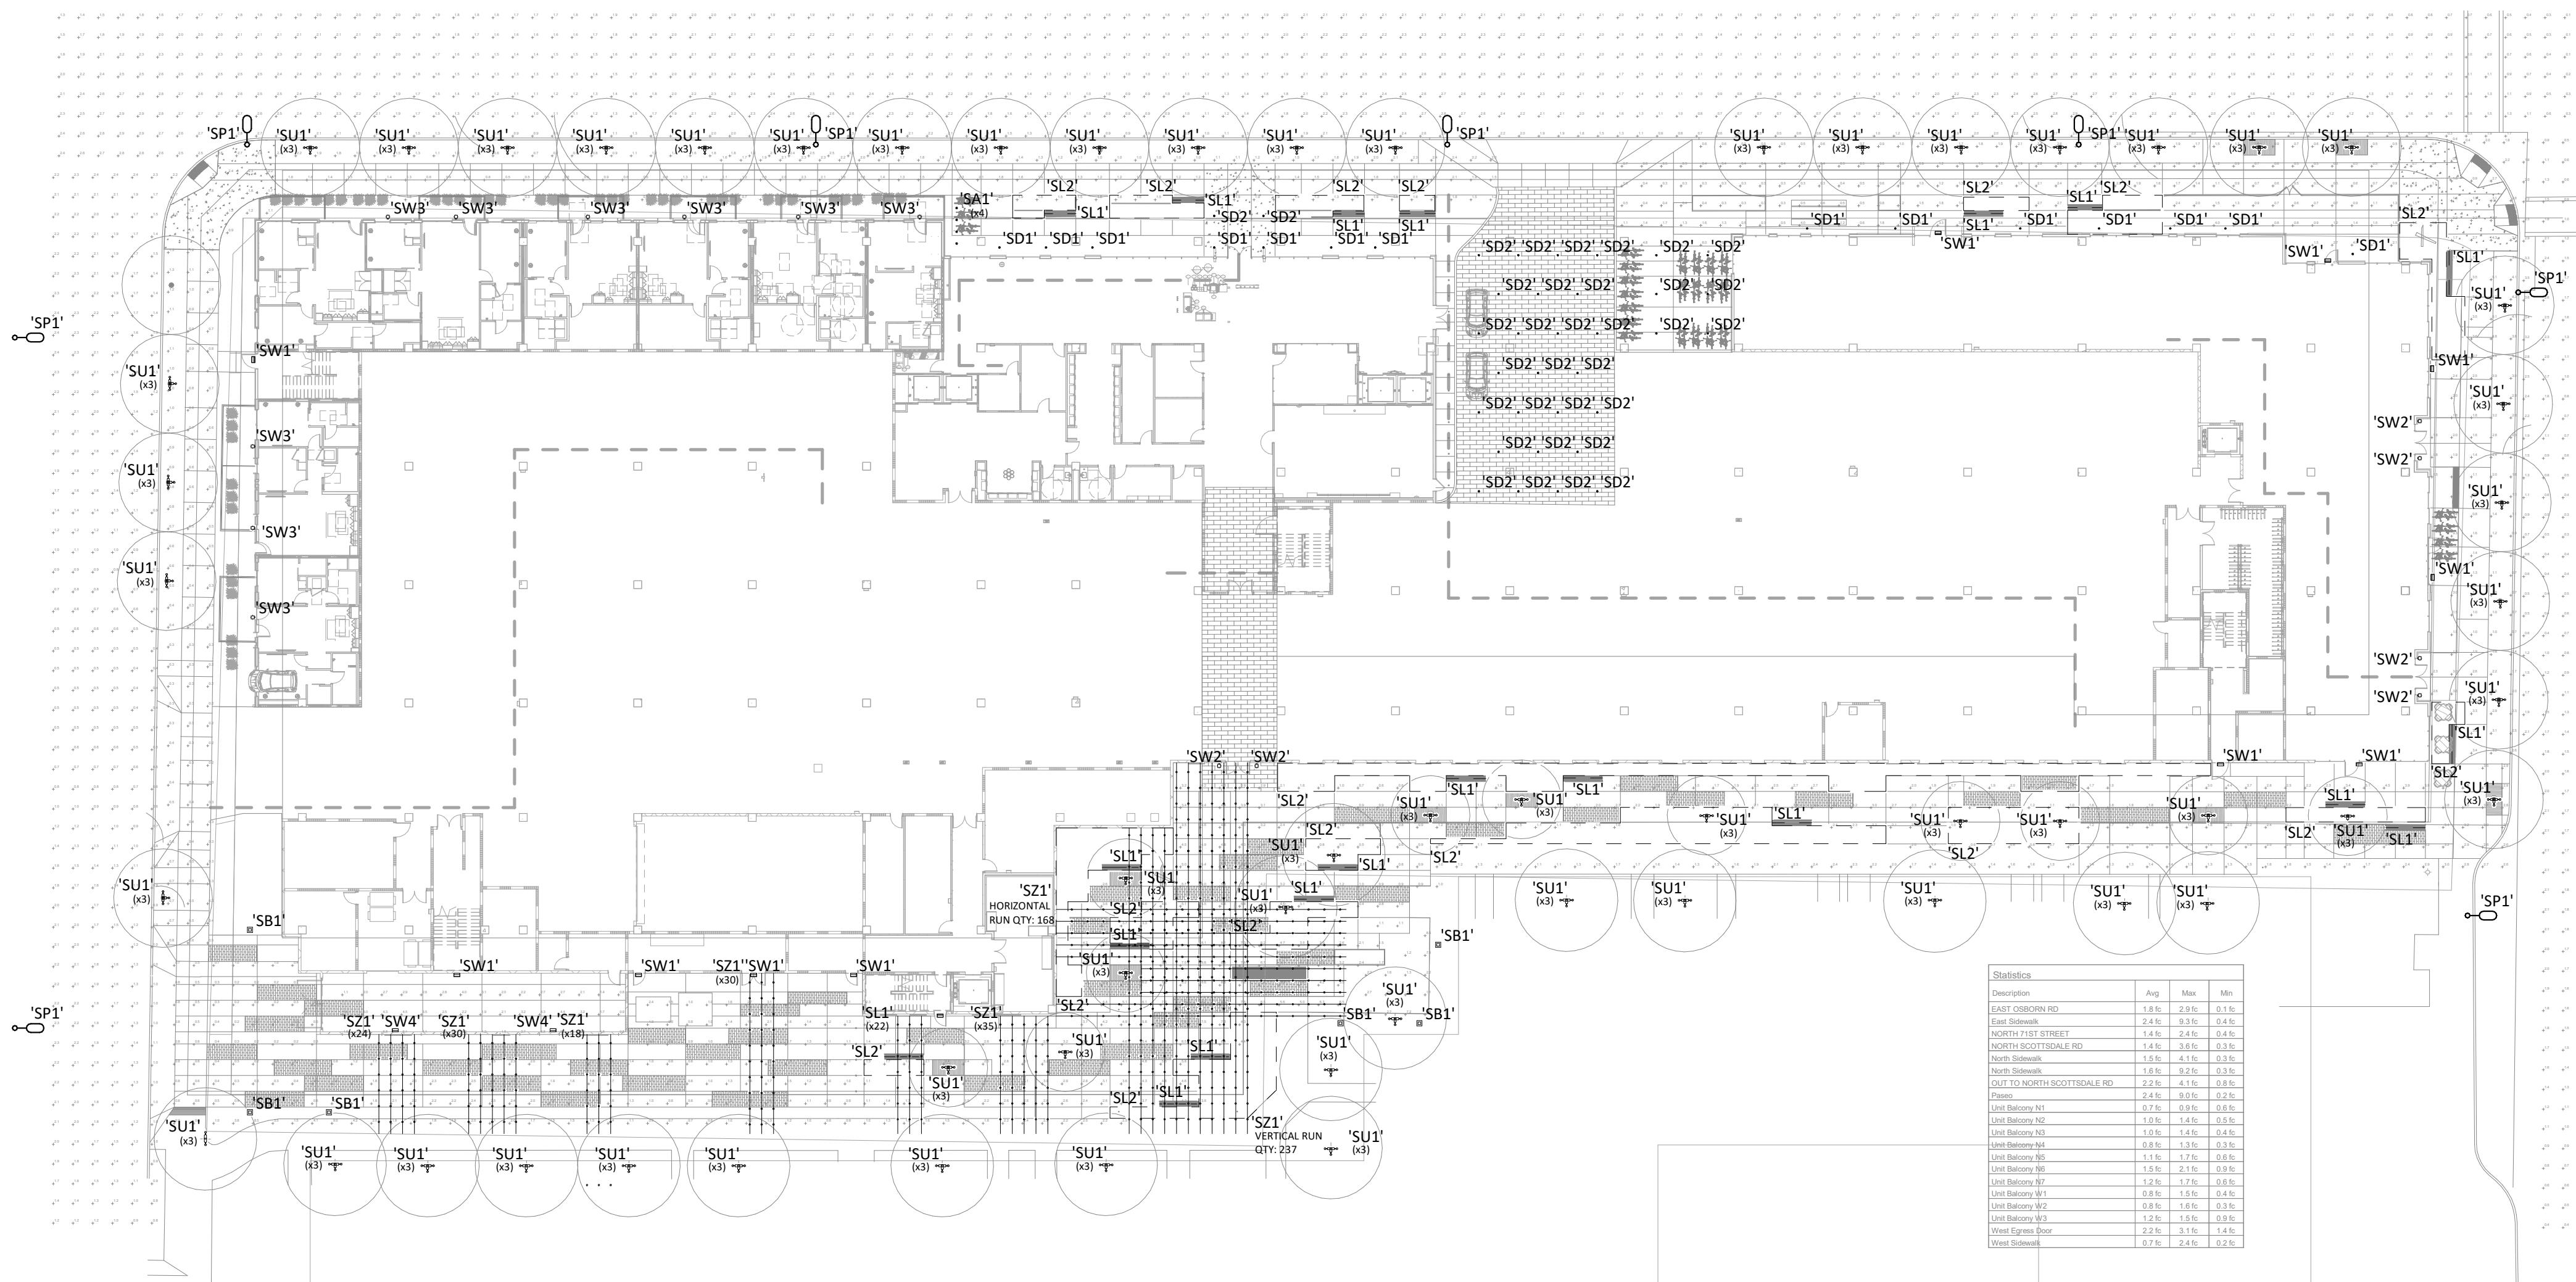

SITE - LIGHTING - LIGHTING

SCALE: 1" = 30'-0"

NOT FOR CONSTRUCTION

Project Name

EMPIRE GROUP

Project Number

057.8211.100

Description

SITE - LIGHTING - LIGHTING

Scale

1" = 30'-0"

LD1.01

- LIGHTING FIXTURE SCHEDULE -

- LIGHTING FIXTURE SCHEDULE -															
SCHEDULE DISPLAY ORDER	TYPE	DESCRIPTION	LAMP DATA							BASIS OF DESIGN			MOUNT TYPE		NOTES
			Fixture Voltage	Dim Type	Lamp Type	Lamp Quantity	Lamp Wattage	Notes	Color Temp	Manufacturer Prelim	Model Prelim	Alternates	Location	Mounting	
AMENITY															
AMENITY	'AD1'	TYPICAL RECESSED AMENITY DOWNLIGHT	120 V	0-10V	LED	1	9 W		3000 K	TBD	TBD			CEILING	RECESSED
AMENITY	'AF-L8'	SURFACE MOUNT IN DISCOVERY CENTER	120 V	0-10V	LED	1	28 W		0 K	TBD	TBD			CEILING	
AMENITY	'AF-L8a'	SMALL SURFACE MOUNT IN DISCOVERY CENTER	120 V	0-10V	LED	1	28 W		0 K	TBD	TBD			CEILING	
AMENITY	'AF-L12'	FLUSH MOUNT AT MC LOBBY AND LIVING	120 V		LED	1	50 W		3000 K	TBD	TBD			CEILING	SURFACE
AMENITY	'AF-L15'	MC SUN ROOM FLUSH MOUNT	120 V		LED	1	54 W		3000 K	TBD	TBD			CEILING	SURFACE
AMENITY	'AF-L16'	MC SALON FLUSH MOUNT	120 V		LED	1	7 W		3000 K	TBD	TBD			CEILING	ID TYPE 'L-16'
AMENITY	'AF-L20'	SURFACE MOUNT AT AL DISCOVERY RM SALES AND PDR	120 V	0-10V	LED	1	35 W		2700 K	TBD	TBD			CEILING	
AMENITY	'AL1'	CURVED TAPELIGHT FOR COVE			LED	1	1 W		0 K	TBD	TBD				
AMENITY	'AL2'	TAPELIGHT AND CHANNEL IN CORRIDOR COVES	24 V	0-10V	LED	1	3 W	3.3 W/FT	3000 K	TBD	TBD			COVE	SURFACE
AMENITY	'AP-L1'	LINEAR PENDANT AT RECEPTION DESK	120 V	0-10V	LED	1	22 W		3000 K	TBD	TBD			CEILING	
AMENITY	'AP-L2'	PENDANT AT BISTRO COUNTER	120 V	0-10V	LED	1	10 W		3000 K	TBD	TBD			CEILING	
AMENITY	'AP-L5'	PENDANT IN AA MAIL ROOM	120/277 V	ELV	LED	1	18 W		3000 K	TBD	TBD			CEILING	
AMENITY	'AP-L6'	PENDANT IN MC LOBBY AND AL MAIL RM	120 V	ELV	LED	1	129 W		3000 K	TBD	TBD			CEILING	
AMENITY	'AP-L7'	TBD CHANDELIER	120 V		LED	1	1 W		3000 K	TBD	TBD			CEILING	
AMENITY	'AP-L11'	SMALL PENDANT IN LVL 2 PUBLIC RR	12 V	0-10V	LED	1	6 W		3000 K	TBD	TBD			CEILING	
AMENITY	'AP-L17'	SMALL PENDANT IN MC DINING AREA	120 V		LED	1	40 W		3000 K	TBD	TBD			CEILING	SURFACE
AMENITY	'AP-L18'	LARGE PENDANT IN MC DINING AREA	120 V		LED	1	45 W		2700 K	TBD	TBD			CEILING	SURFACE
AMENITY	'AP-L19'	PENDANT AT AL AND MC RECEPTION	120/277 V		LED	1	38 W		3000 K	TBD	TBD			CEILING	
AMENITY	'AP-L22'	CUSTOM PENDANT IN AL GREAT RM AND CASUAL DINING	120 V	0-10V	LED	1	370 W		3000 K	TBD	TBD				
AMENITY	'AP-L23'	PENDANT IN AL GREAT RM AND CASUAL DINING	120 V		LED	1	12 W		0 K	TBD	TBD			CEILING	
AMENITY	'AW-L3'	SCONCE IN AA MAIN LOBBY AND ELEVATOR LOBBY	120 V	0-10V	LED	1	10 W		3000 K	TBD	TBD			WALL	
AMENITY	'AW-L4'	BOH AND MC BATH SCONCE	120 V	0-10V	LED	1	28 W		0 K	TBD	TBD				
AMENITY	'AW-L9'	SCONCE IN THEATER	120/277 V	0-10V	LED	1	27 W		3000 K	TBD	TBD			WALL	
AMENITY	'AW-L21'	SCONCE IN AL ELEVATOR LOBBY, GREAT RM AND CASUAL DINING	120/277 V	ELV	LED	1	28 W		3000 K	TBD	TBD			WALL	
AMENITY	'AW-L25'	SALON SCONCE	120 V		LED	1	1 W		0 K	TBD	TBD				
CORRIDOR															
CORRIDOR	'CA1'	3" RECESSED WALL WASH	120 V	0-10V	LED	1	9 W		3000 K	TBD	TBD			CEILING	RECESSED
CORRIDOR	'CA2'	ELEVATOR LOBBY MONOPONT	120/277 V	0-10V	LED	1	12 W		3000 K	TBD	TBD			CEILING	SURFACE
CORRIDOR	'CA3'	3" RECESSED DOWNLIGHT	120 V	0-10V	LED	1	9 W		3000 K	TBD	TBD			CEILING	RECESSED
CORRIDOR	'CD1'	TYPICAL RECESSED CORRIDOR DOWNLIGHT	120 V	0-10V	LED	1	9 W		3000 K	TBD	TBD			CEILING	RECESSED
CORRIDOR	'CF1'	CORRIDOR SURFACE MOUNT AT WOOD CEILING	120/277 V	0-10V	LED	1	20 W		3000 K	TBD	TBD			CEILING	SURFACE
CORRIDOR	'CF-L14'	MC CORRIDOR FLUSHMOUNT	120 V		LED	1	54 W		3000 K	TBD	TBD			CEILING	SURFACE
CORRIDOR	'CF-L32'	SURFACE MOUNT IN AA CORRIDORS	120/277 V	NON	LED	1	40 W		3000 K	TBD	TBD			CEILING	SURFACE
CORRIDOR	'CL1'	ELEVATOR LOBBY LINEAR PERIMETER SLOT	120 V	0-10V	LED	1	20 W		3000 K	TBD	TBD			CEILING	RECESSED
CORRIDOR	'CW-L13'	MC UNIT ENTRY SCONCE	120/277 V		LED	1	12 W		3000 K	TBD	TBD			WALL	SURFACE
CORRIDOR	'CW-L31'	AA UNIT ENTRY SCONCE	120 V		LED	1	5 W		3000 K	TBD	TBD			WALL	<varies>
CORRIDOR	'CW-L33'	AL UNIT ENTRY SCONCE	120 V		LED	1	10 W		3000 K	TBD	TBD			WALL	<varies>
SITE															
SITE	'SA1'	ENTRY CANOPY WALLWASH	120/277 V		LED	1	14 W		3000 K	TBD	TBD			CEILING	RECESSED
SITE	'SB1'	SITE BOLLARD	120/277 V		LED	1	14 W		3000 K	TBD	TBD			Hardscape	SURFACE
SITE	'SD1'	ENTRY CANOPY DOWNLIGHT (25 DEG)	120/277 V		LED	1	14 W		3000 K	TBD	TBD			CEILING	RECESSED
SITE	'SD2'	ENTRY CANOPY DOWNLIGHT (50 DEG)	120/277 V		LED	1	14 W		3000 K	TBD	TBD			CEILING	RECESSED
SITE	'SL1'	LINEAR BENCH TAPELIGHT	24 V		LED	1	6 W	6 W/FT	3000 K	TBD	TBD			Hardscape	SURFACE
SITE	'SL2'	LINEAR PLANTER BED TAPELIGHT	24 V		LED	1	6 W	6 W/FT	3000 K	TBD	TBD			PLANTER	SURFACE
SITE	'SP1'	SITE ROADWAY COBRAHEAD	120/277 V		LED	1	105 W		4000 K	TBD	TBD			STREET	POLE
SITE	'SU1'	LANDSCAPE TREE UPLIGHT	120 V		LED	1	15 W		3000 K	TBD	TBD			PLANTER	SURFACE
SITE	'SW1'	WALL PACK	120/277 V		LED	1	26 W		3000 K	TBD	TBD			WALL	SURFACE
SITE	'SW2'	ENTRY SCONCE	120 V		LED	1	24 W		3000 K	TBD	TBD			WALL	SURFACE
SITE	'SW3'	GROUND LEVEL UNIT ENTRY SCONCE	120/277 V		LED	1	10 W		3000 K	TBD	TBD			WALL	SURFACE
SITE	'SW4'	BOH WALL PACK	120/277 V		LED	1	26 W		3000 K	TBD	TBD			WALL	SURFACE
SITE	'SZ1'	PASEO STRING LIGHTS	120 V		LED	1	1 W		3000 K	TBD	TBD			CATENARY	BUILDING/POLE
UNITS															
UNITS	'UC'	UNIT CLOSET LIGHT	120 V		LED	1	18 W		3000 K	TBD	TBD			CEILING	SURFACE
UNITS	'UCL'	TAPELIGHT IN UNIT CLOSET	120 V		LED	1	6 W	6 W/FT	3000 K	TBD	TBD			WALL	SURFACE
UNITS	'UE'	UNIT ENTRY LIGHT	120 V		LED	1	15 W		3000 K	TBD	TBD			CEILING	SURFACE
UNITS	'UF1'	AL & MC UNIT FAN	120 V		LED	1	44 W		3000 K	TBD	TBD			CEILING	SURFACE
UNITS	'UF2'	AA UNIT FAN	120 V		LED	1	44 W		3000 K	TBD	TBD			CEILING	SURFACE
UNITS	'UFM1'	AL & MC LIVING ROOM FLUSH MOUNT	120 V		LED	1	60 W		3000 K	TBD	TBD			CEILING	SURFACE
UNITS	'UFM2'	AA LIVING ROOM FLUSH MOUNT	120 V		LED										

Gänsler

2575 E Camelback Road
Suite 175
Phoenix, AZ 85016
United States
Office Information

el 6025234900
ax 6025234949

SYDNOR

Tel 480.206.4593

△ Date Description

Seal / Signature

NOT FOR CONSTRUCTION

Project Name

EMPIRE GROUP

| Project Num

057 8211 100

Description

LIGHTING FIXTURE SCHEDULE

| Scale

| D0 02